




S.NO	D/W	NOS.	WIDTH	HEIGHT	LINTEL	SILL
01	D1	04	950	2100	2100	00
02	D2	01	742	2100	2100	00
03	D3	01	600	2100	2100	00
04	D4	02	1395	2100	2100	00
05	W1	01	1025	1100	2100	1000
06	V1	01	400	400	2100	1700

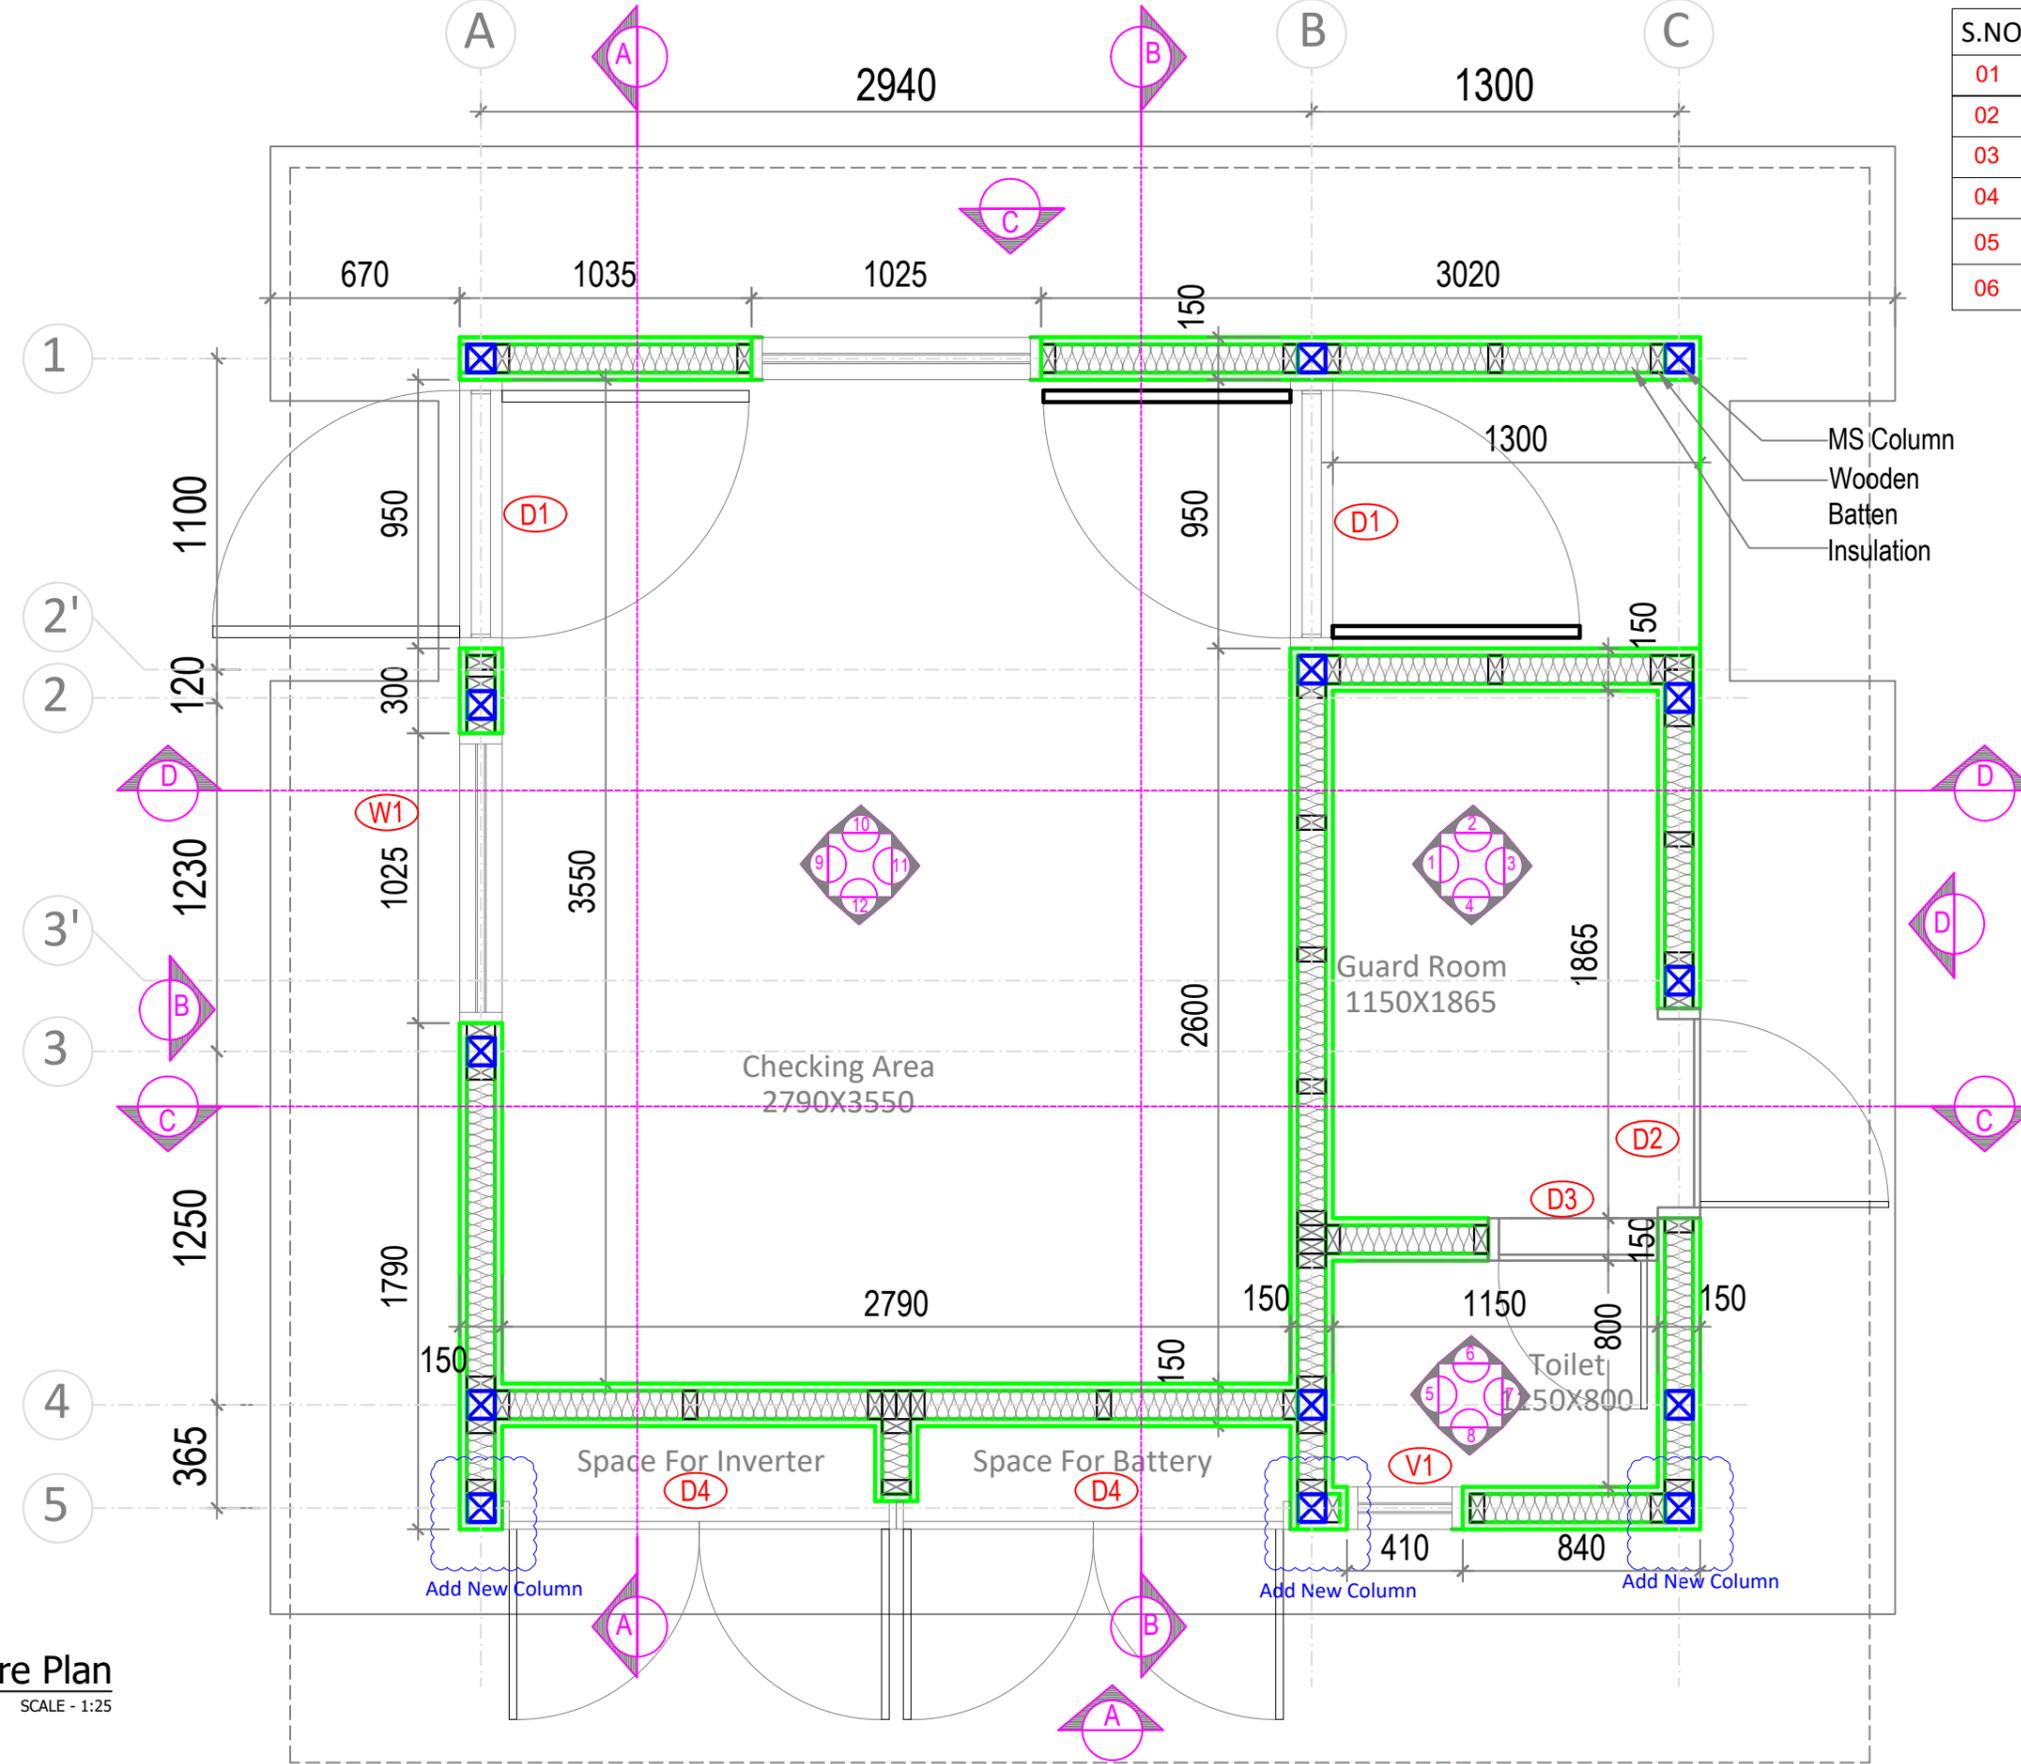

**02 Architecture Plan**  
SCALE - 1:25

**NOTE:**  
THIS DRAWING IS A COPYRIGHT. IT IS THE PROPERTY OF STUDIO VANRO AND IS NOT TO BE REPRODUCED, COPIED, HANDED OVER TO A THIRD PARTY OR USED FOR ANY PURPOSE OTHER THAN THAT FOR WHICH IT HAS BEEN LOANED.


**GENERAL NOTES:**  
ALL DIMENSIONS INDICATED ARE IN MILLIMETER UNLESS MENTIONED OTHERWISE  
ALL DIMENSIONS ARE TO BE CROSS CHECKED AT SITE AND ANY DISCREPANCY SHALL BE BROUGHT TO NOTICE BEFORE EXECUTION.  
ALL SERVICE DRAWINGS SHALL BE READ IN CONJUNCTION WITH THIS DRAWING AND OTHER DETAILS, ANY DISCREPANCY WHATSOEVER SHALL BE BROUGHT TO NOTICE BEFORE EXECUTION.


S.NO	DATE	DRAWN	CHECKED	VERIFIED	REMARKS
01	22.01.2025	MP	VN	SD/SSG	RO_Drawing Drawn

REVISIONS	NO.	DATE	DESCRIPTION



CLIENT	J D Centre of Art		PROJECT	J D Centre of Art, Bhubaneswar	
ARCHITECT	Studio VanRO		DRAWING	SECURITY ROOM - ARCHITECTURE PLAN	
STRUCTURAL CONSULTANT	Mahendra Raj Consultants Pvt. Ltd		SCALE	1:25@A4	COMPUTER FILE
MUSEUM DESIGN	Siddhartha Das Studio		DATE	22-01-2025	JDCA- Security Room -20250204-MP
SANITARY, ELECTRICAL, HVAC, FIRE FIGHTING CONSULTANT			DRAWN BY	MAHESH PRAKASH	CHECKED BY
			DATE	22-01-2025	VIVEK NAMDEV
			DRAWING TITLE		

 

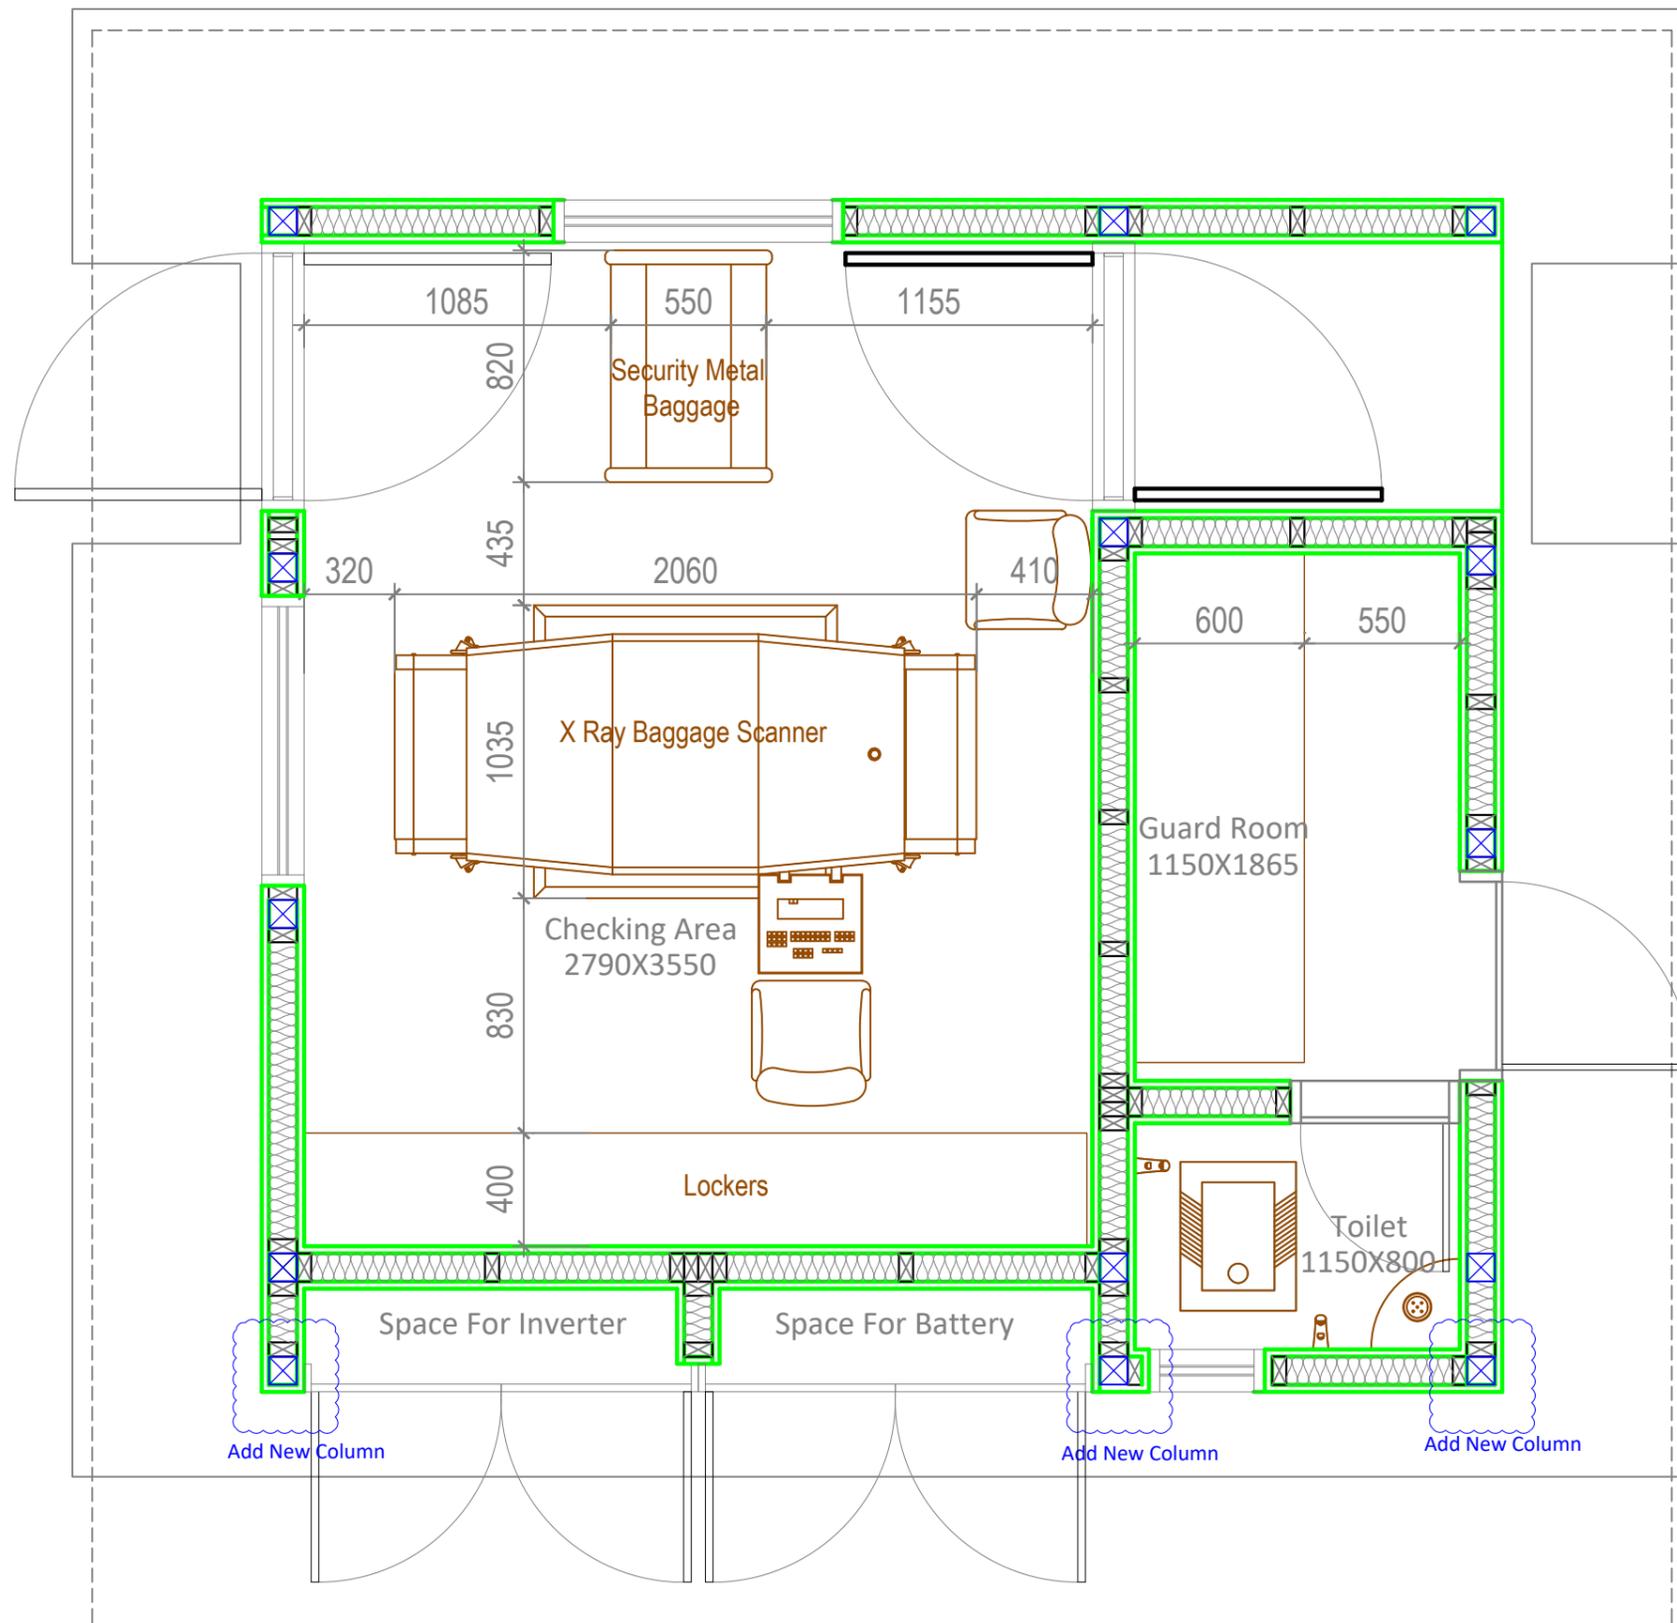


**03 Furniture Plan**  
SCALE - 1:25

**NOTE:**  
THIS DRAWING IS A COPYRIGHT. IT IS THE PROPERTY OF STUDIO VANRO AND IS NOT TO BE REPRODUCED, COPIED, HANDED OVER TO A THIRD PARTY OR USED FOR ANY PURPOSE OTHER THAN THAT FOR WHICH IT HAS BEEN LOANED.


**GENERAL NOTES:**  
ALL DIMENSIONS INDICATED ARE IN MILLIMETER UNLESS MENTIONED OTHERWISE  
ALL DIMENSIONS ARE TO BE CROSS CHECKED AT SITE AND ANY DISCREPANCY SHALL BE BROUGHT TO NOTICE BEFORE EXECUTION.


ALL SERVICE DRAWINGS SHALL BE READ IN CONJUNCTION WITH THIS DRAWING AND OTHER DETAILS, ANY DISCREPANCY WHATSOEVER SHALL BE BROUGHT TO NOTICE BEFORE EXECUTION.

S.NO	DATE	DRAWN	CHECKED	VERIFIED	REMARKS
01	22.01.2025	MP	VN	SD/SSG	RO_Drawing Drawn

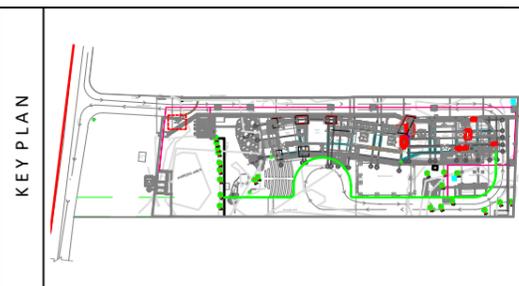

CLIENT		PROJECT	
J D Centre of Art		J D Centre of Art, Bhubaneswar	
ARCHITECT		DRAWING	
Studio VanRO		SECURITY ROOM-FURNITURE PLAN	
STRUCTURAL CONSULTANT		SCALE	COMPUTER FILE
Mahendra Raj Consultants Pvt. Ltd		1:25@A4	JDCA- Security Room -20250204-MP
MUSEUM DESIGN		DRAWN BY	CHECKED BY
Siddhartha Das Studio		MAHESH PRAKASH	VIVEK NAMDEV
SANITARY, ELECTRICAL, HVAC, FIRE FIGHTING CONSULTANT		DATE	DRAWING TITLE
		22-01-2025	

 

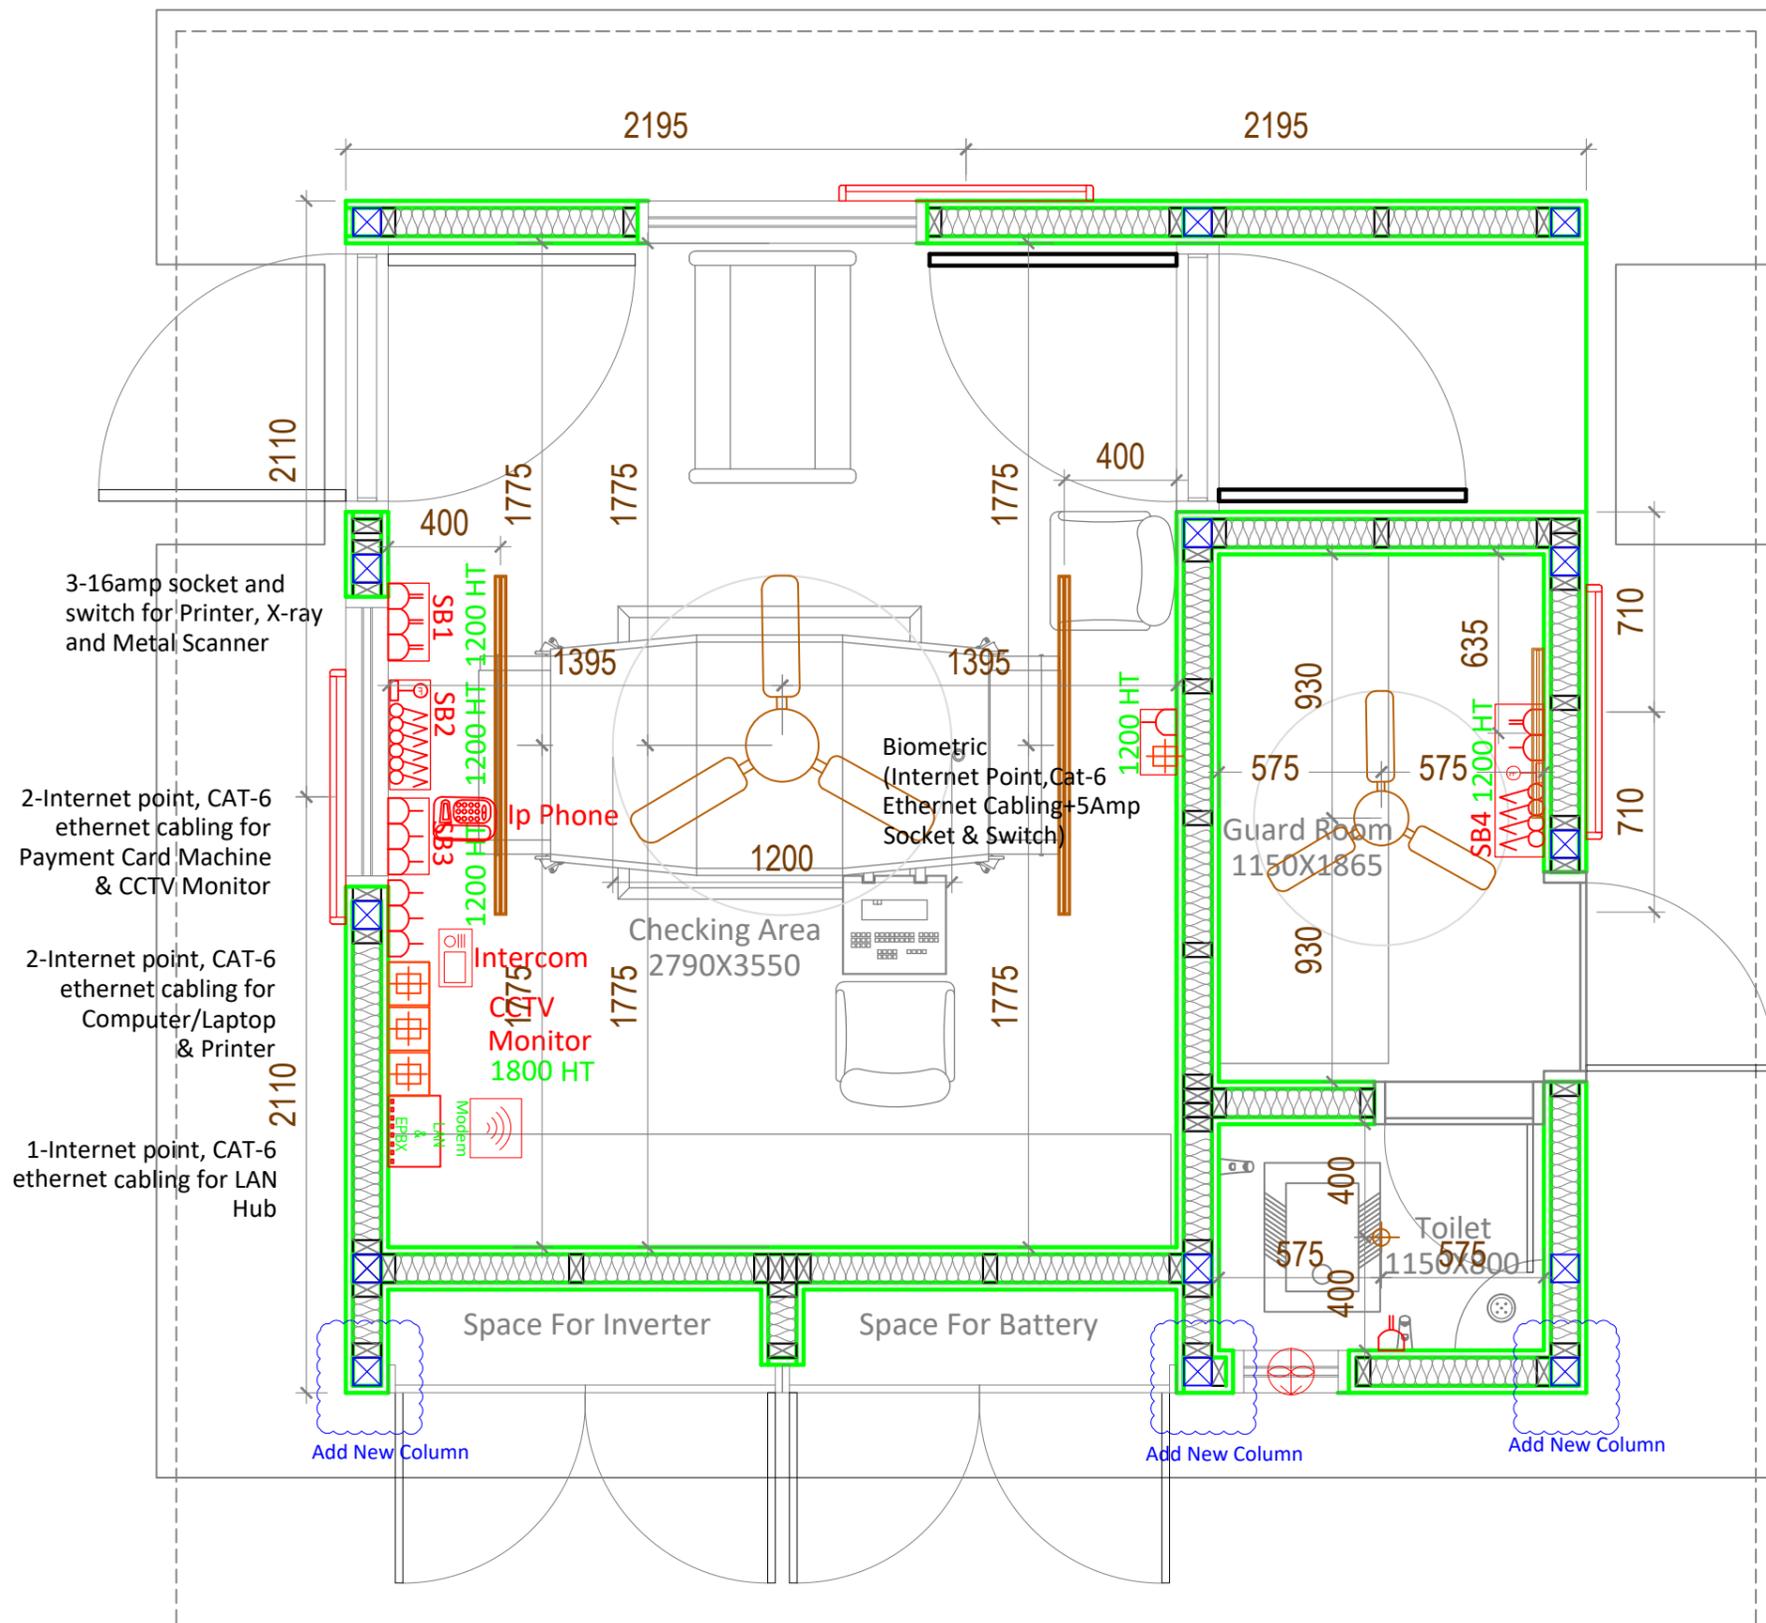

LIGHTING LEGEND	
SYMBOL	DESCRIPTION
	NORMAL SWITCH
	FAN REGULATOR
	75W CEILING FAN (1200 MM)
	EXHAUST FAN
	28W CEILING MOUNTED T5 TUBE LIGHT
	LIGHT
POWER LEGEND	
	6A SOCKET WITH SWITCH
	16A SOCKET WITH SWITCH
	WIFI ROUTER INTERCOM
	DATA OUTLET
	IP Phone


**04 Electrical Plan**  
SCALE - 1:25

NOTE:  
THIS DRAWING IS A COPYRIGHT. IT IS THE PROPERTY OF STUDIO VANRO AND IS NOT TO BE REPRODUCED, COPIED, HANDED OVER TO A THIRD PARTY OR USED FOR ANY PURPOSE OTHER THAN THAT FOR WHICH IT HAS BEEN LOANED.


GENERAL NOTES:  
ALL DIMENSIONS INDICATED ARE IN MILLIMETER UNLESS MENTIONED OTHERWISE  
ALL DIMENSIONS ARE TO BE CROSS CHECKED AT SITE AND ANY DISCREPANCY SHALL BE BROUGHT TO NOTICE BEFORE EXECUTION.

ALL SERVICE DRAWINGS SHALL BE READ IN CONJUNCTION WITH THIS DRAWING AND OTHER DETAILS, ANY DISCREPANCY WHATSOEVER SHALL BE BROUGHT TO NOTICE BEFORE EXECUTION.


S.NO	DATE	DRAWN	CHECKED	VERIFIED	REMARKS
01	22.01.2025	MP	VN	SD/SSG	RO_Drawing Drawn

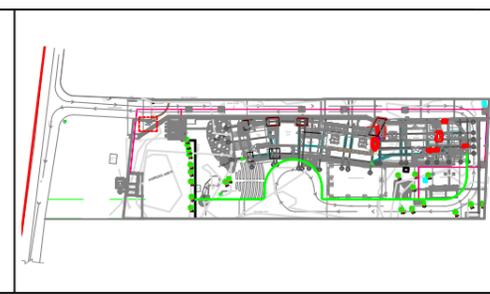

CLIENT	J D Centre of Art		PROJECT	J D Centre of Art, Bhubaneswar	
ARCHITECT	Studio VanRO		DRAWING	SECURITY ROOM-ELECTRICAL PLAN	
STRUCTURAL CONSULTANT	Mahendra Raj Consultants Pvt. Ltd	SCALE	1:40@A3	COMPUTER FILE	JDCA- Security Room -20250204-MP
MUSEUM DESIGN	Siddhartha Das Studio	DRAWN BY	MAHESH PRAKASH	CHECKED BY	VIVEK NAMDEV
SANITARY, ELECTRICAL, HVAC, FIRE FIGHTING CONSULTANT		DATE	22-01-2025	DRAWING TITLE	

 



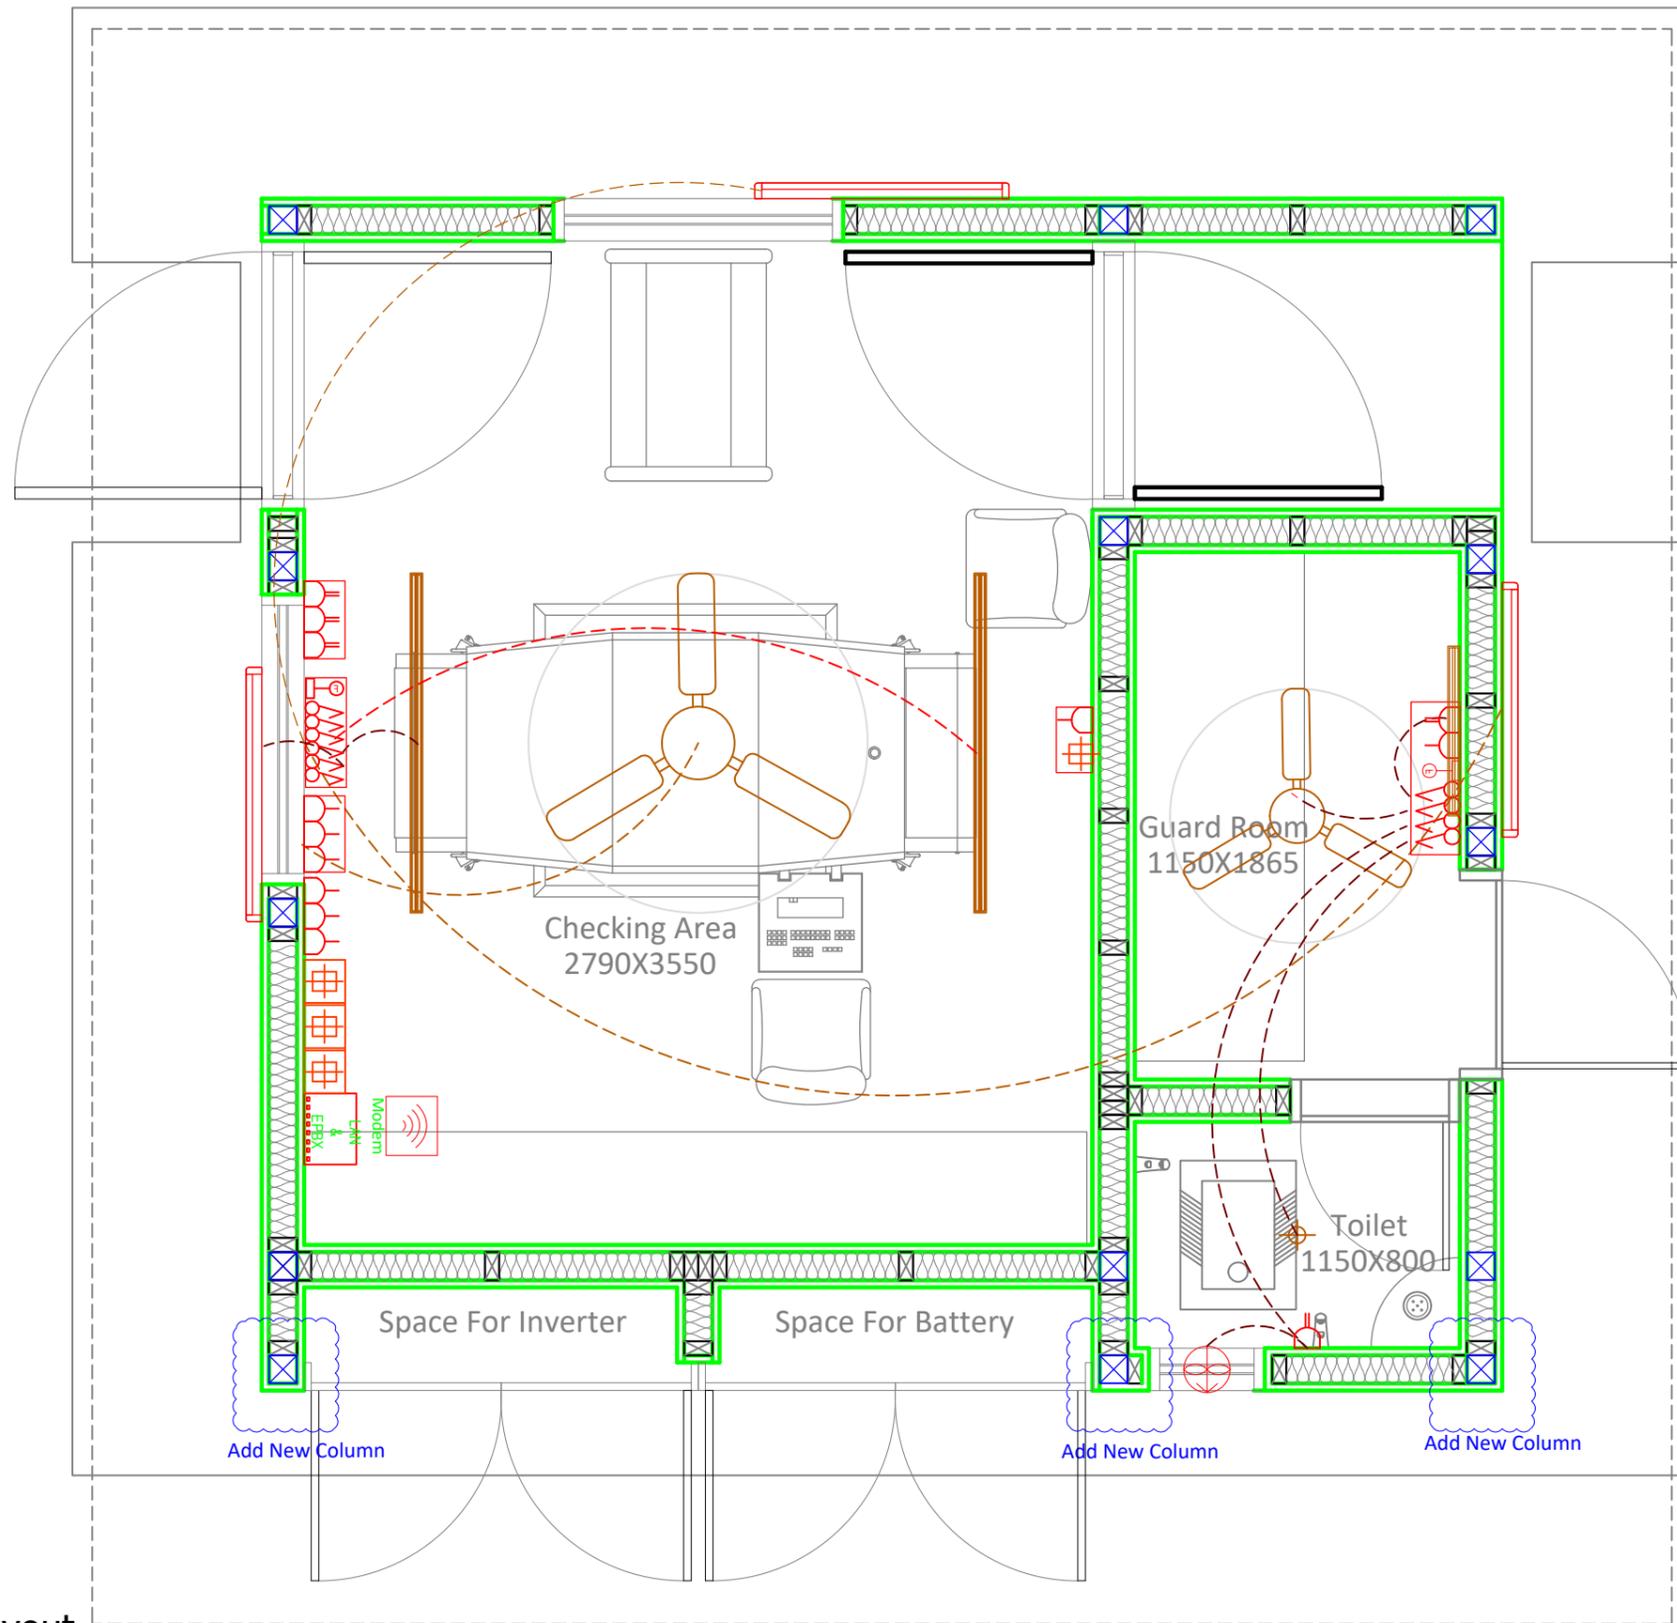

**06** Looping Layout  
SCALE - 1:25


**NOTE:**  
THIS DRAWING IS A COPYRIGHT. IT IS THE PROPERTY OF STUDIO VANRO AND IS NOT TO BE REPRODUCED, COPIED, HANDED OVER TO A THIRD PARTY OR USED FOR ANY PURPOSE OTHER THAN THAT FOR WHICH IT HAS BEEN LOANED.

**GENERAL NOTES:**  
ALL DIMENSIONS INDICATED ARE IN MILLIMETER UNLESS MENTIONED OTHERWISE  
ALL DIMENSIONS ARE TO BE CROSS CHECKED AT SITE AND ANY DISCREPANCY SHALL BE BROUGHT TO NOTICE BEFORE EXECUTION.  
ALL SERVICE DRAWINGS SHALL BE READ IN CONJUNCTION WITH THIS DRAWING AND OTHER DETAILS, ANY DISCREPANCY WHATSOEVER SHALL BE BROUGHT TO NOTICE BEFORE EXECUTION.


S.NO	DATE	DRAWN	CHECKED	VERIFIED	REMARKS
01	22.01.2025	MP	VN	SD/SSG	RO_Drawing Drawn



CLIENT	J D Centre of Art		PROJECT	J D Centre of Art, Bhubaneswar	
ARCHITECT	Studio VanRO		DRAWING	SECURITY ROOM-LOOPING PLAN	
STRUCTURAL CONSULTANT	Mahendra Raj Consultants Pvt. Ltd		SCALE	1:25@A3	COMPUTER FILE
MUSEUM DESIGN	Siddhartha Das Studio		DATE	22-01-2025	JDCA- Security Room -20250204-MP
SANITARY, ELECTRICAL, HVAC, FIRE FIGHTING CONSULTANT			DRAWN BY	MAHESH PRAKASH	CHECKED BY
					VIVEK NAMDEV
			DRAWING TITLE		

 

SYMBOL	DESCRIPTION
	Water Tap
	Indian Commode
	Corner Wash Basin

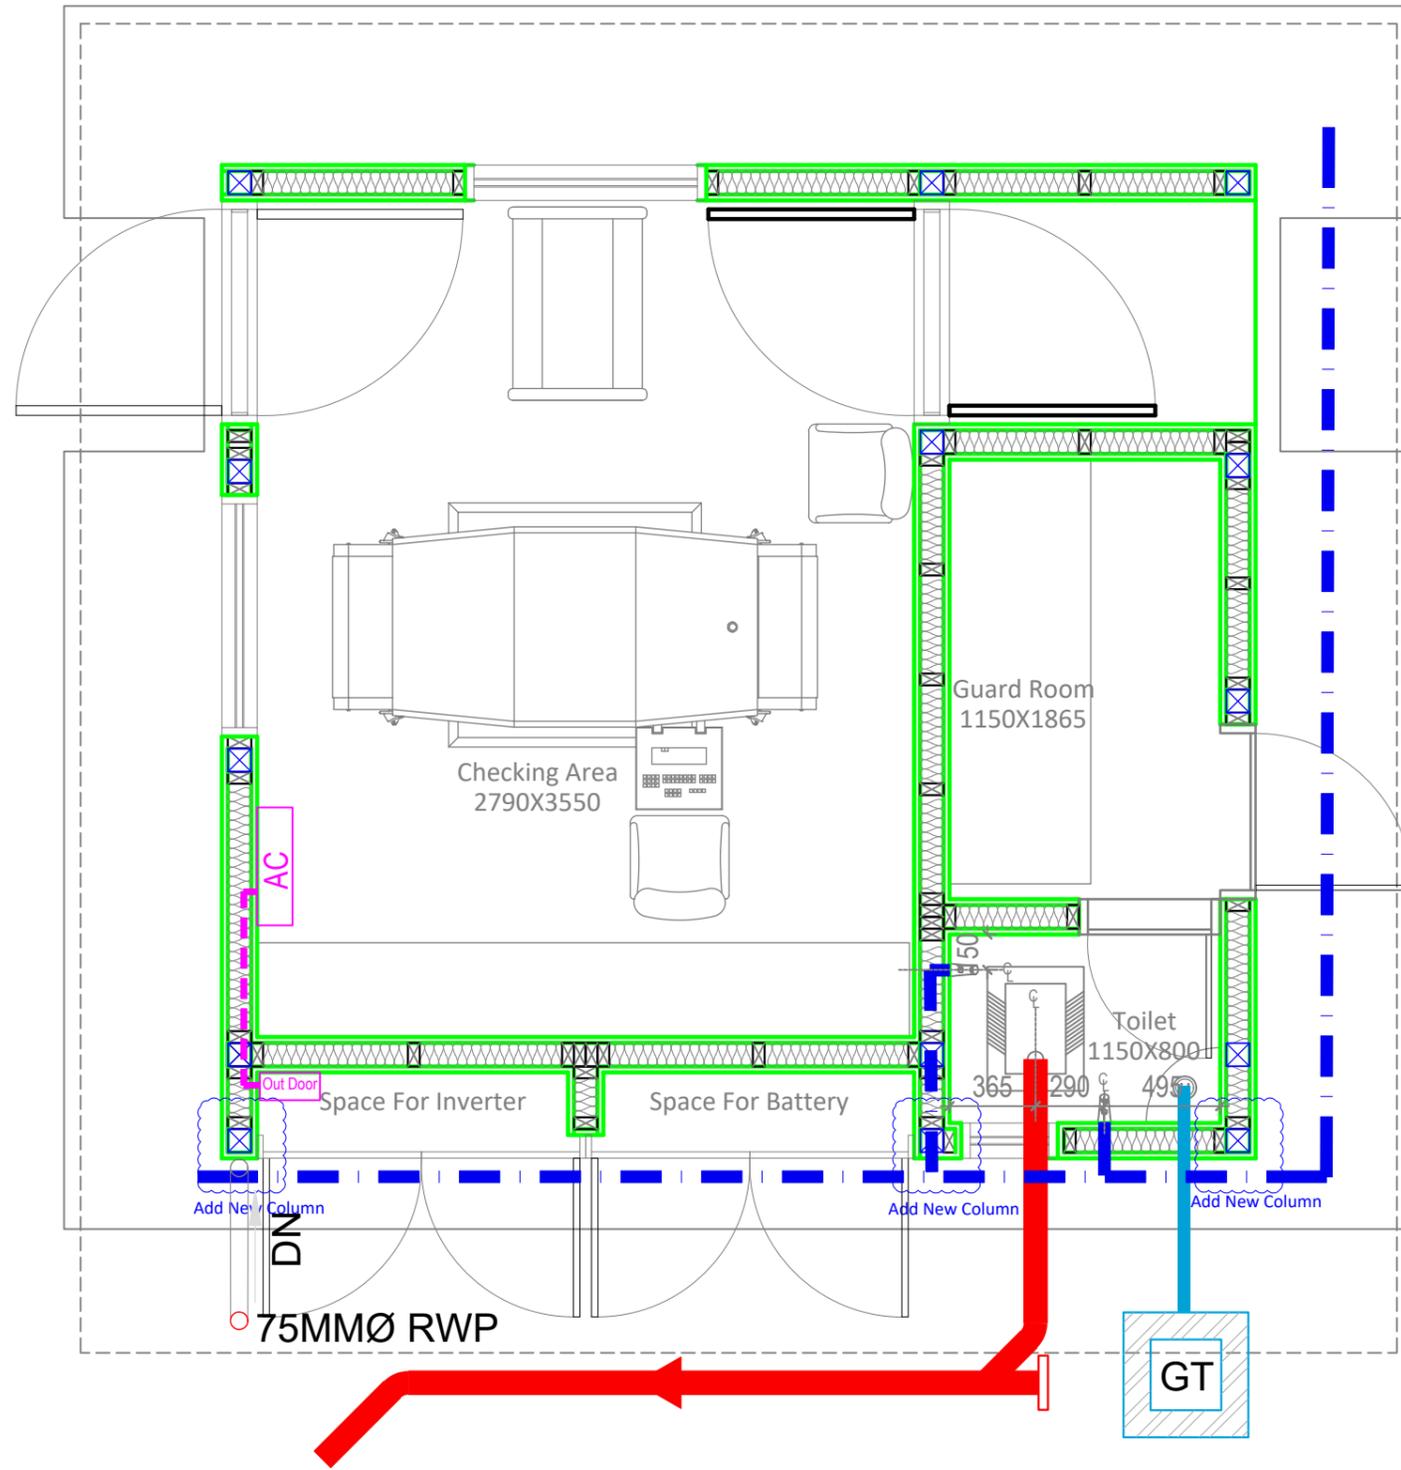


**07 Plumbing Layout**  
SCALE - 1:30


**NOTE:**  
THIS DRAWING IS A COPYRIGHT. IT IS THE PROPERTY OF STUDIO VANRO AND IS NOT TO BE REPRODUCED, COPIED, HANDED OVER TO A THIRD PARTY OR USED FOR ANY PURPOSE OTHER THAN THAT FOR WHICH IT HAS BEEN LOANED.

**GENERAL NOTES:**  
ALL DIMENSIONS INDICATED ARE IN MILLIMETER UNLESS MENTIONED OTHERWISE  
ALL DIMENSIONS ARE TO BE CROSS CHECKED AT SITE AND ANY DISCREPANCY SHALL BE BROUGHT TO NOTICE BEFORE EXECUTION.  
ALL SERVICE DRAWINGS SHALL BE READ IN CONJUNCTION WITH THIS DRAWING AND OTHER DETAILS, ANY DISCREPANCY WHATSOEVER SHALL BE BROUGHT TO NOTICE BEFORE EXECUTION.


S.NO	DATE	DRAWN	CHECKED	VERIFIED	REMARKS
01	22.01.2025	MP	VN	SD/SSG	RO_Drawing Drawn

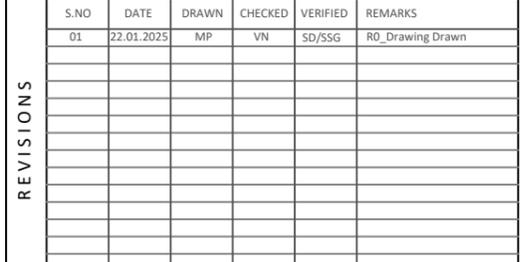

CLIENT	J D Centre of Art	PROJECT	J D Centre of Art, Bhubaneswar
ARCHITECT	Studio VanRO	DRAWING	SECURITY ROOM-PLUMBING LAYOUT
STRUCTURAL CONSULTANT	Mahendra Raj Consultants Pvt. Ltd	SCALE	1:30 @ A3
MUSEUM DESIGN	Siddhartha Das Studio	COMPUTER FILE	JDCA- Security Room -20250204-MP
SANITARY, ELECTRICAL, HVAC, FIRE FIGHTING CONSULTANT		DRAWN BY	MAHESH PRAKASH
		CHECKED BY	VIVEK NAMDEV
		DATE	22-01-2025
		DRAWING TITLE	

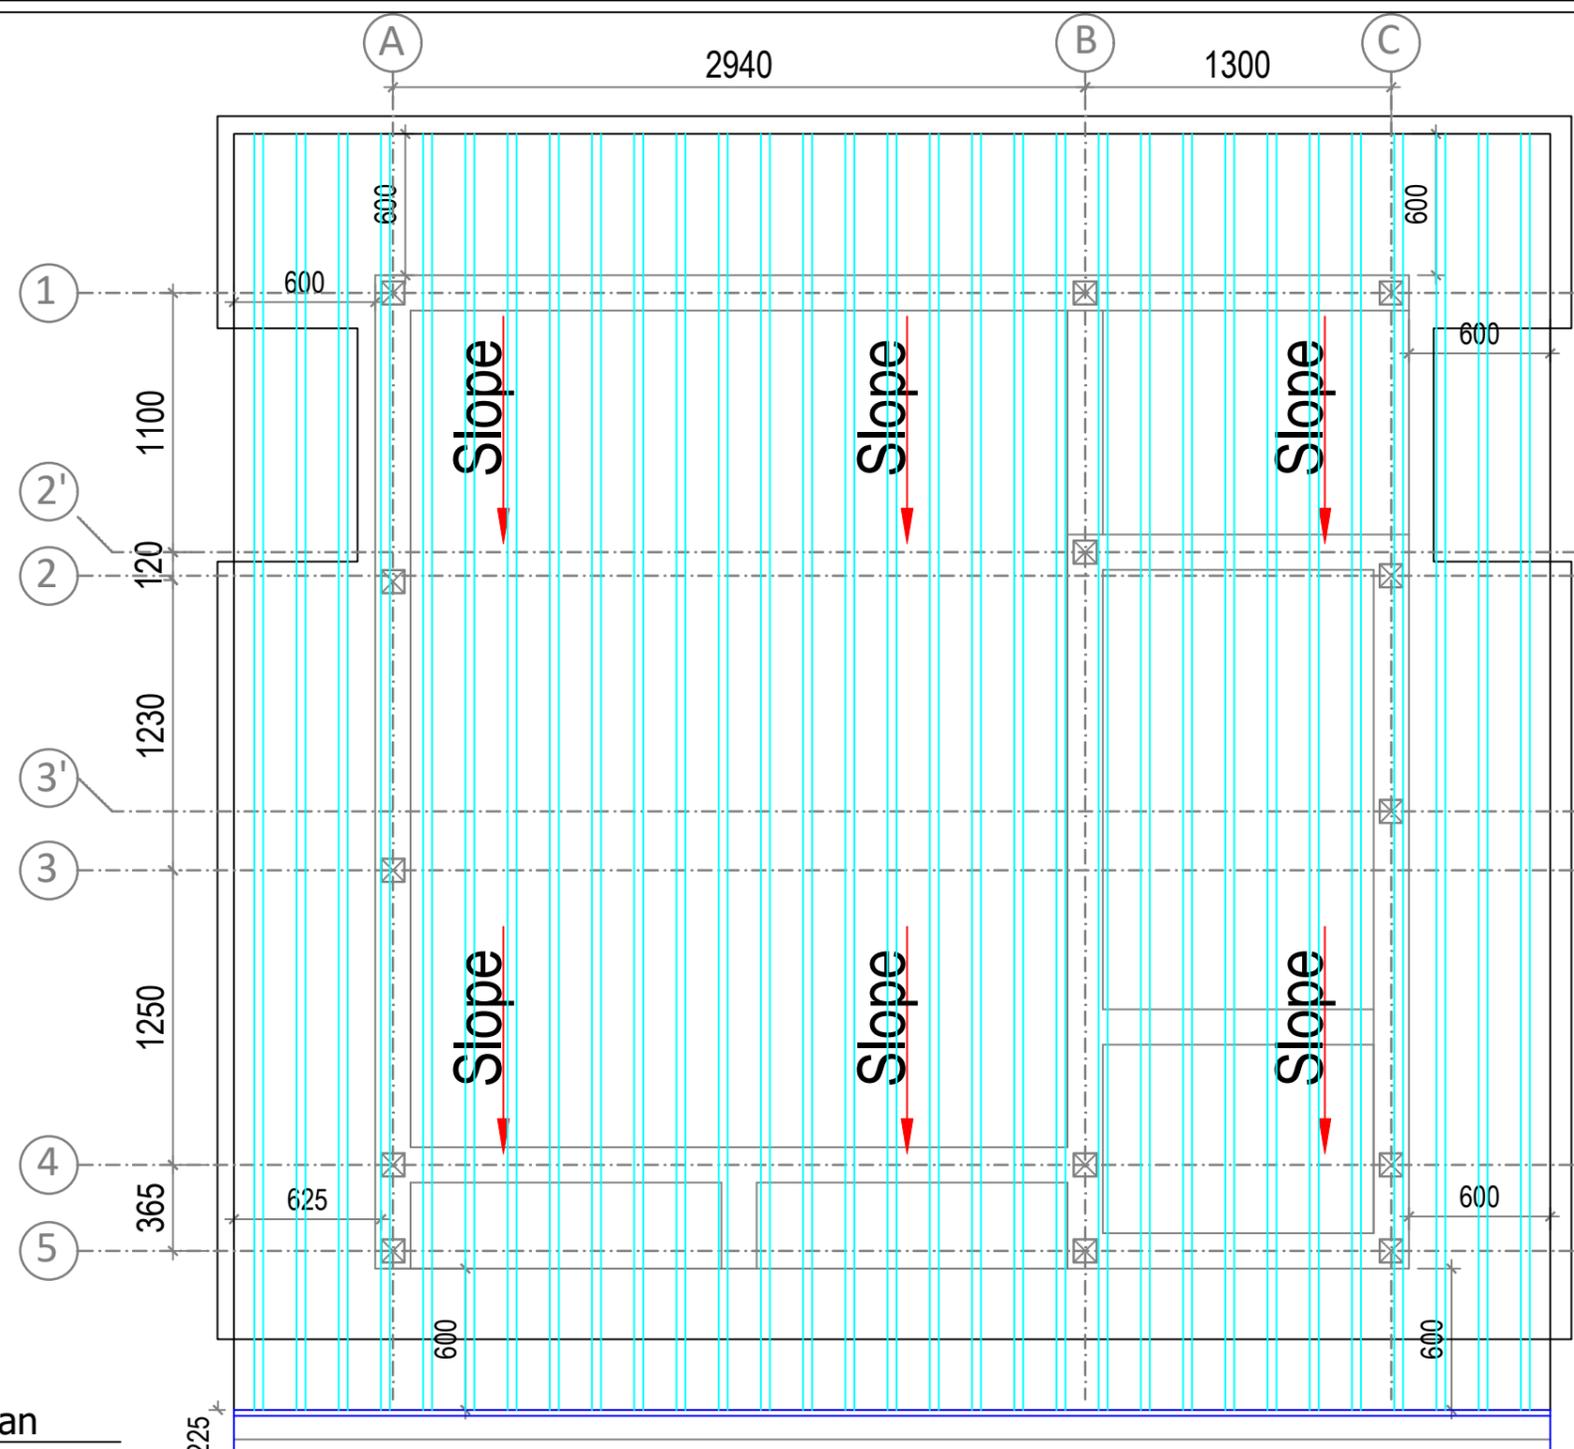

08 Roof Plan  
SCALE - 1:30

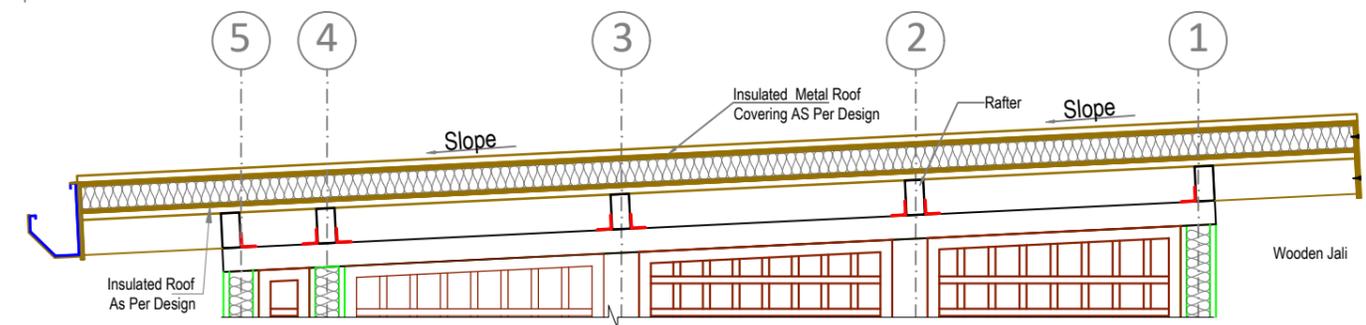

09 Roof Section  
SCALE - 1:30

NOTE:  
THIS DRAWING IS A COPYRIGHT. IT IS THE PROPERTY OF STUDIO VANRO AND IS NOT TO BE REPRODUCED, COPIED, HANDED OVER TO A THIRD PARTY OR USED FOR ANY PURPOSE OTHER THAN THAT FOR WHICH IT HAS BEEN LOANED.

GENERAL NOTES:  
ALL DIMENSIONS INDICATED ARE IN MILLIMETER UNLESS MENTIONED OTHERWISE  
ALL DIMENSIONS ARE TO BE CROSS CHECKED AT SITE AND ANY DISCREPANCY SHALL BE BROUGHT TO NOTICE BEFORE EXECUTION.  
ALL SERVICE DRAWINGS SHALL BE READ IN CONJUNCTION WITH THIS DRAWING AND OTHER DETAILS, ANY DISCREPANCY WHATSOEVER SHALL BE BROUGHT TO NOTICE BEFORE EXECUTION.


S.NO	DATE	DRAWN	CHECKED	VERIFIED	REMARKS
01	22.01.2025	MP	VN	SD/SSG	RO_Drawing Drawn

S.NO	DATE	DRAWN	CHECKED	VERIFIED	REMARKS




CLIENT	J D Centre of Art	PROJECT	J D Centre of Art, Bhubaneswar
ARCHITECT	Studio VanRO	DRAWING	SECURITY ROOM-ROOF PLAN
STRUCTURAL CONSULTANT	Mahendra Raj Consultants Pvt. Ltd	SCALE	1:25@A3
MUSEUM DESIGN	Siddhartha Das Studio	COMPUTER FILE	JDCA- Security Room -20250204-MP
SANITARY, ELECTRICAL, HVAC, FIRE FIGHTING CONSULTANT		DRAWN BY	MAHESH PRAKASH
		CHECKED BY	VIVEK NAMDEV
		DATE	22-01-2025
		DRAWING TITLE	




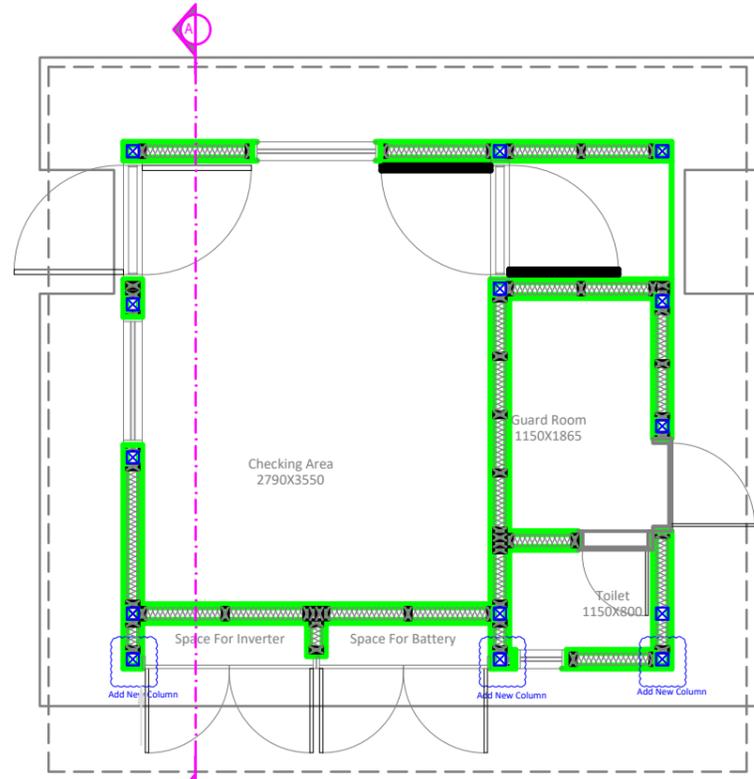

**01 Key Plan**  
SCALE - 1:80

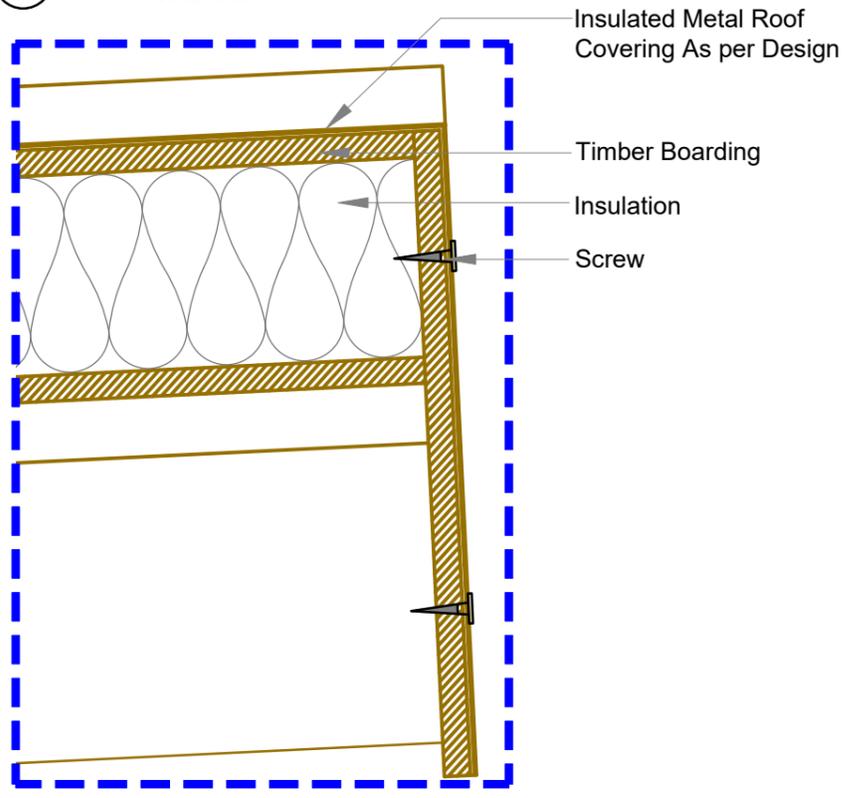

**03 Detail-A**  
SCALE - 1:5


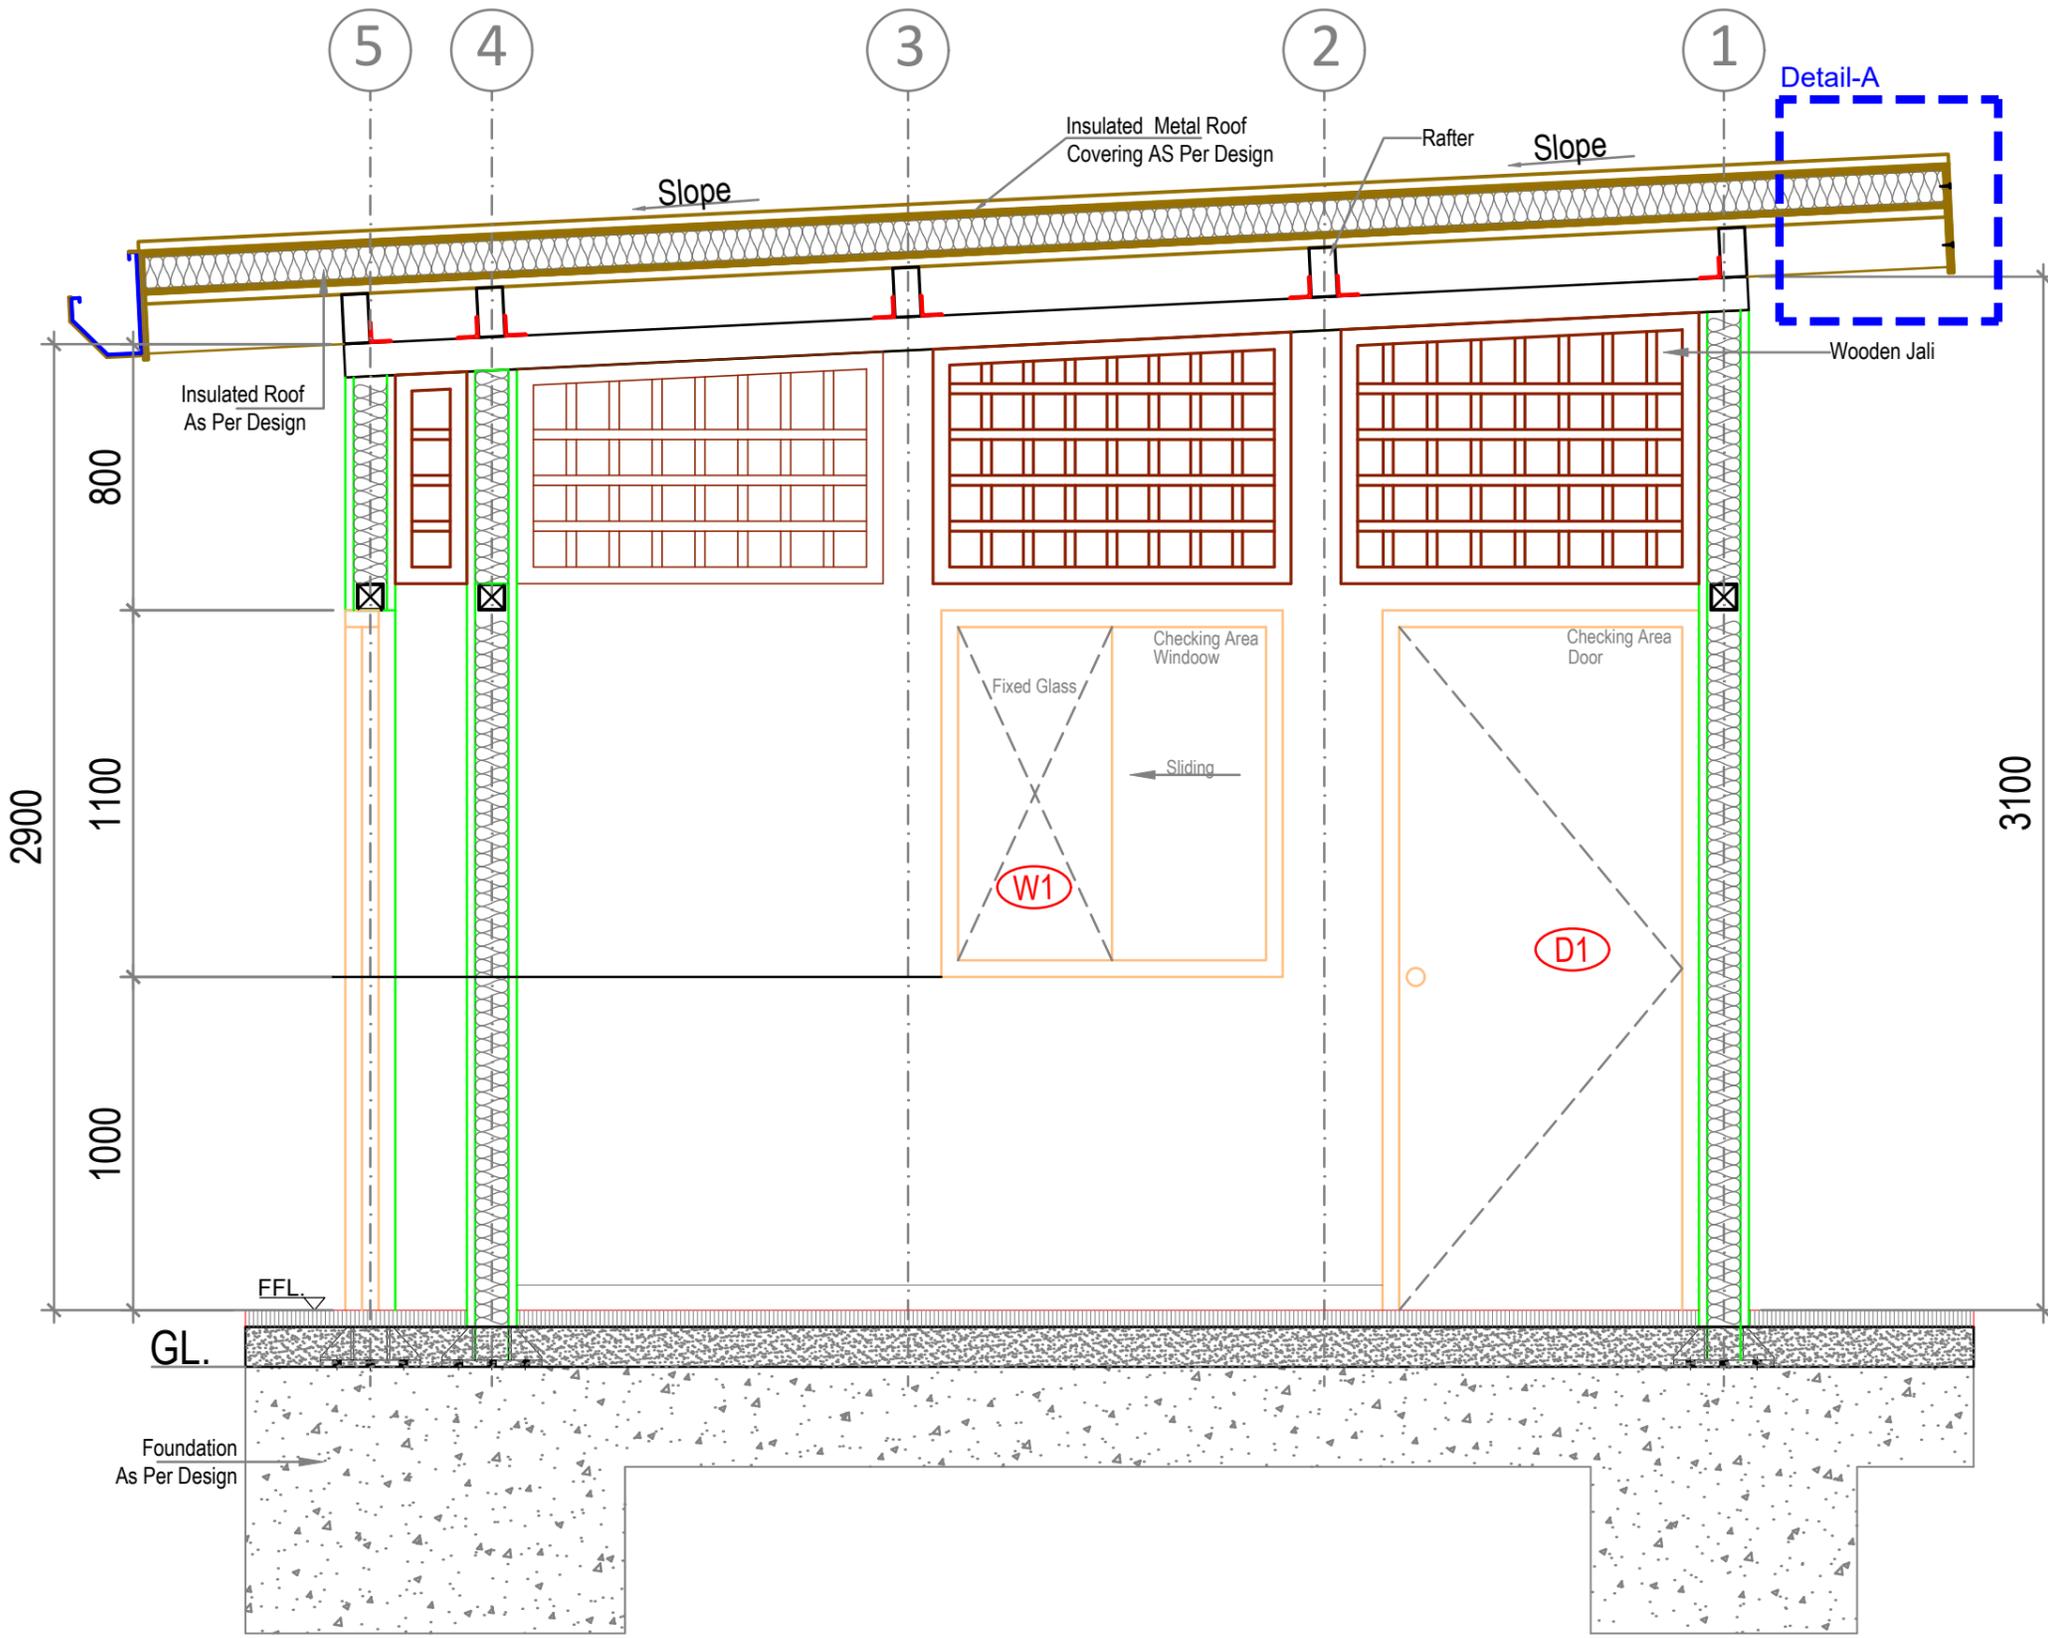


**02 Section-A**  
SCALE - 1:30


**NOTE:**  
THIS DRAWING IS A COPYRIGHT. IT IS THE PROPERTY OF STUDIO VANRO AND IS NOT TO BE REPRODUCED, COPIED, HANDED OVER TO A THIRD PARTY OR USED FOR ANY PURPOSE OTHER THAN THAT FOR WHICH IT HAS BEEN LOANED.

**GENERAL NOTES:**  
ALL DIMENSIONS INDICATED ARE IN MILLIMETER UNLESS MENTIONED OTHERWISE  
ALL DIMENSIONS ARE TO BE CROSS CHECKED AT SITE AND ANY DISCREPANCY SHALL BE BROUGHT TO NOTICE BEFORE EXECUTION.  
ALL SERVICE DRAWINGS SHALL BE READ IN CONJUNCTION WITH THIS DRAWING AND OTHER DETAILS, ANY DISCREPANCY WHATSOEVER SHALL BE BROUGHT TO NOTICE BEFORE EXECUTION.


S.NO	DATE	DRAWN	CHECKED	VERIFIED	REMARKS
01	22.01.2025	MP	VN	SD/SSG	RO_Drawing Drawn

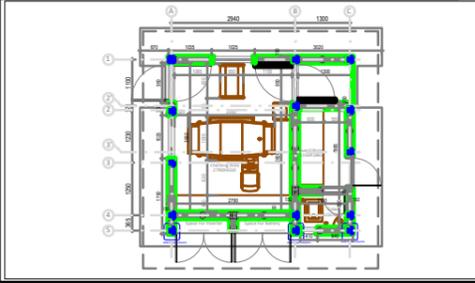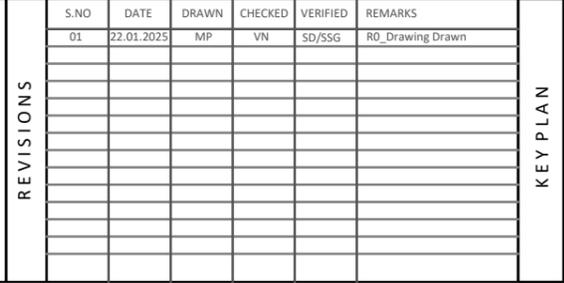


CLIENT		PROJECT	
J D Centre of Art		J D Centre of Art, Bhubaneswar	
ARCHITECT		DRAWING	
Studio VanRO		SECURITY ROOM-SECTION-A	
STRUCTURAL CONSULTANT		SCALE	COMPUTER FILE
Mahendra Raj Consultants Pvt. Ltd		1:30 @ A3	JDCA- Security Room -20250204-MP
MUSEUM DESIGN		DRAWN BY	CHECKED BY
Siddhartha Das Studio		MAHESH PRAKASH	VIVEK NAMDEV
SANITARY, ELECTRICAL, HVAC, FIRE FIGHTING CONSULTANT		DATE	DRAWING TITLE
		22-01-2025	

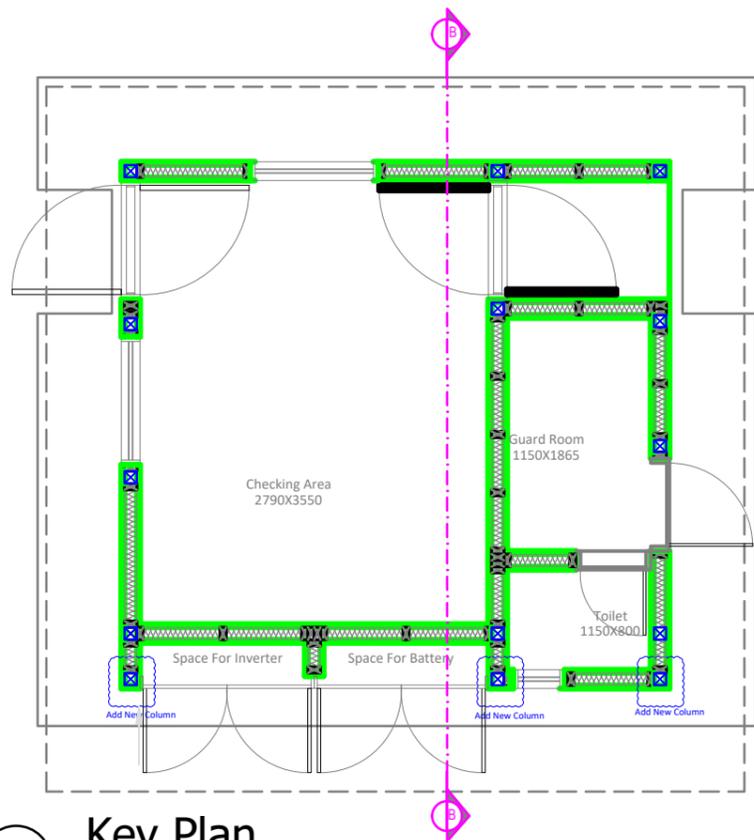

**01 Key Plan**  
SCALE - 1:80

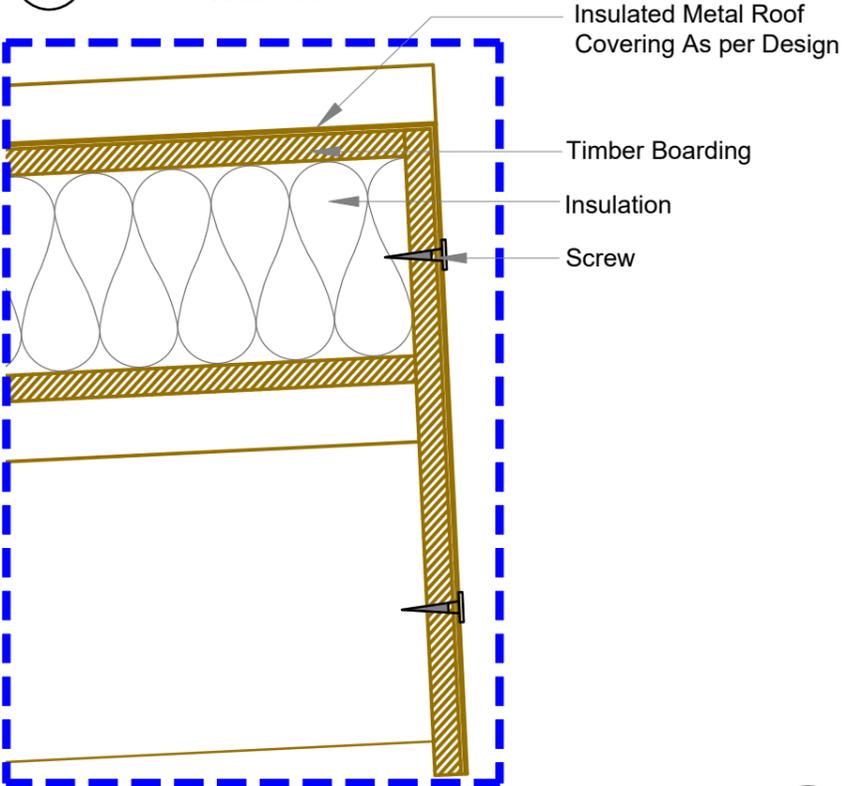

**03 Detail-A**  
SCALE - 1:5

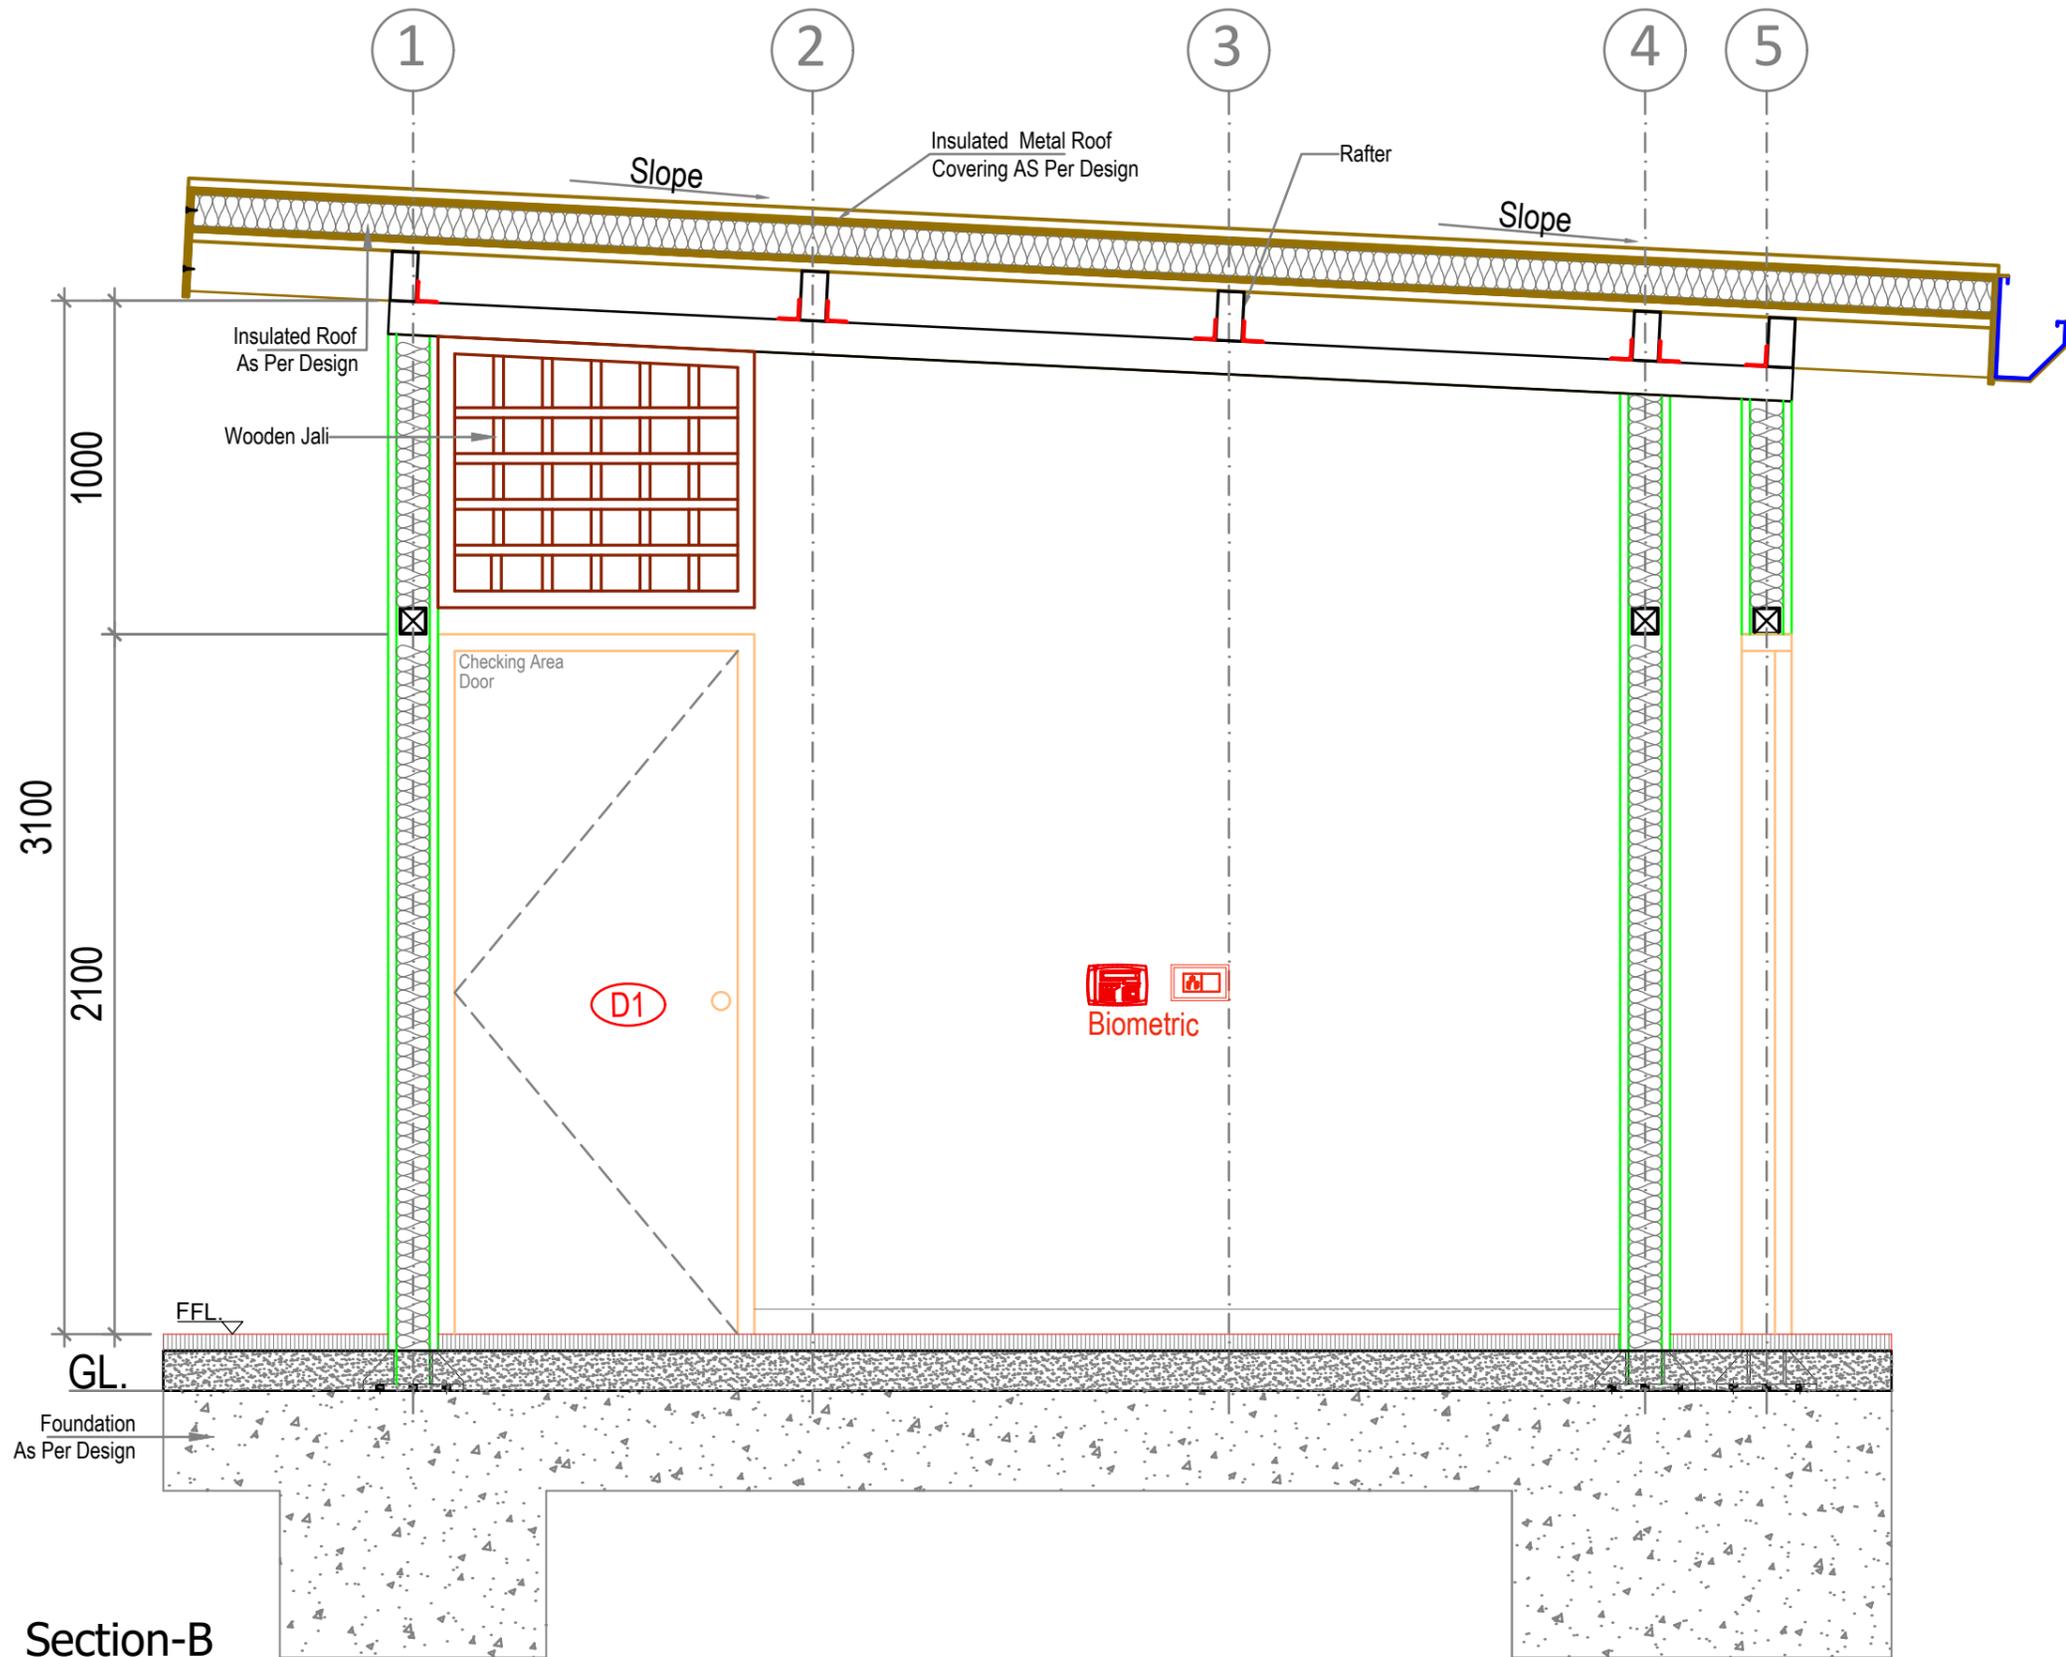

**02 Section-B**  
SCALE - 1:30




Biometric


NOTE:  
THIS DRAWING IS A COPYRIGHT. IT IS THE PROPERTY OF STUDIO VANRO AND IS NOT TO BE REPRODUCED, COPIED, HANDED OVER TO A THIRD PARTY OR USED FOR ANY PURPOSE OTHER THAN THAT FOR WHICH IT HAS BEEN LOANED.

GENERAL NOTES:  
ALL DIMENSIONS INDICATED ARE IN MILLIMETER UNLESS MENTIONED OTHERWISE  
ALL DIMENSIONS ARE TO BE CROSS CHECKED AT SITE AND ANY DISCREPANCY SHALL BE BROUGHT TO NOTICE BEFORE EXECUTION.  
ALL SERVICE DRAWINGS SHALL BE READ IN CONJUNCTION WITH THIS DRAWING AND OTHER DETAILS, ANY DISCREPANCY WHATSOEVER SHALL BE BROUGHT TO NOTICE BEFORE EXECUTION.


S.NO	DATE	DRAWN	CHECKED	VERIFIED	REMARKS
01	22.01.2025	MP	VN	SD/SSG	RO_Drawing Drawn

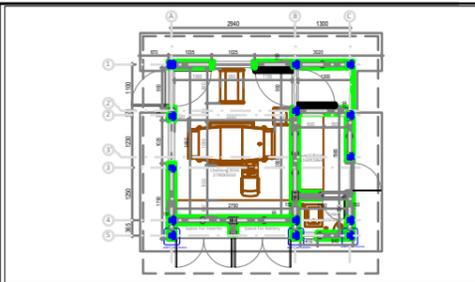


CLIENT	J D Centre of Art		PROJECT	J D Centre of Art, Bhubaneshwar	
ARCHITECT	Studio VanRO		DRAWING	SECURITY ROOM-SECTION-B	
STRUCTURAL CONSULTANT	Mahendra Raj Consultants Pvt. Ltd		SCALE	1:30 @ A3	COMPUTER FILE
MUSEUM DESIGN	Siddhartha Das Studio		DRAWN BY	MAHESH PRAKASH	CHECKED BY
SANITARY, ELECTRICAL, HVAC, FIRE FIGHTING CONSULTANT			DATE	22-01-2025	VIVEK NAMDEV
			DRAWING TITLE		

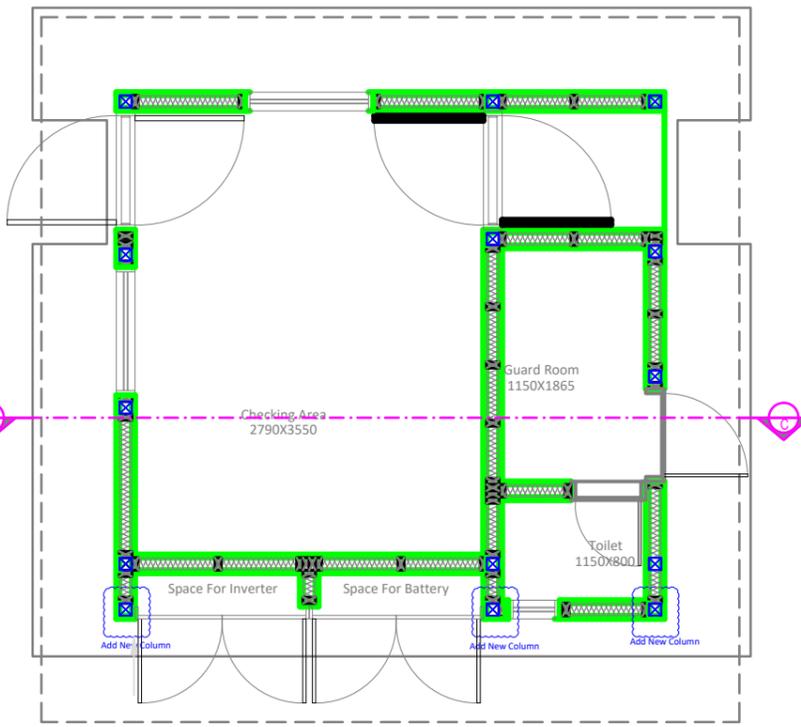

01 Key Plan  
SCALE - 1:80

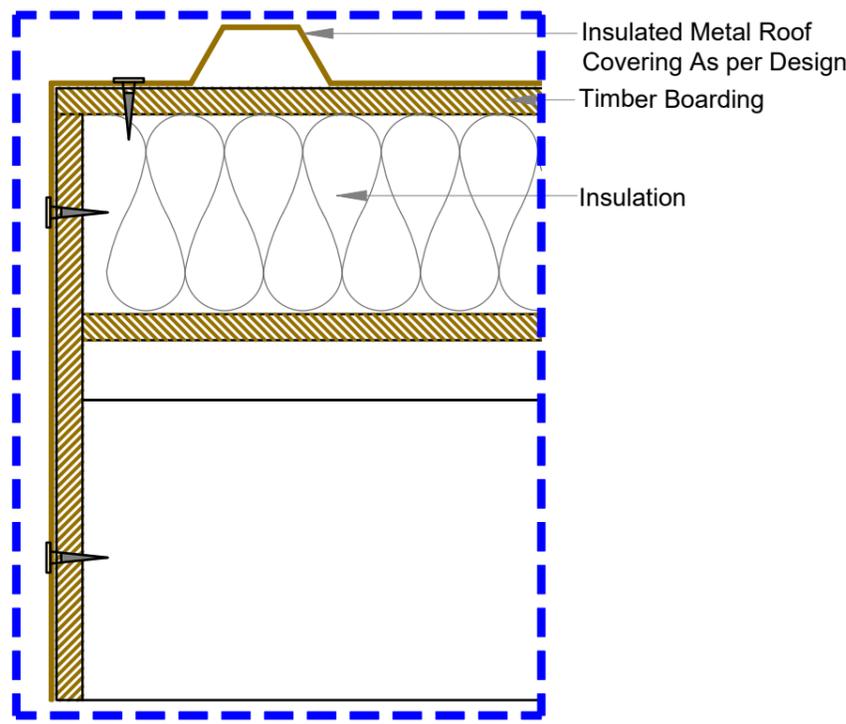

02 Detail-B  
SCALE - 1:5

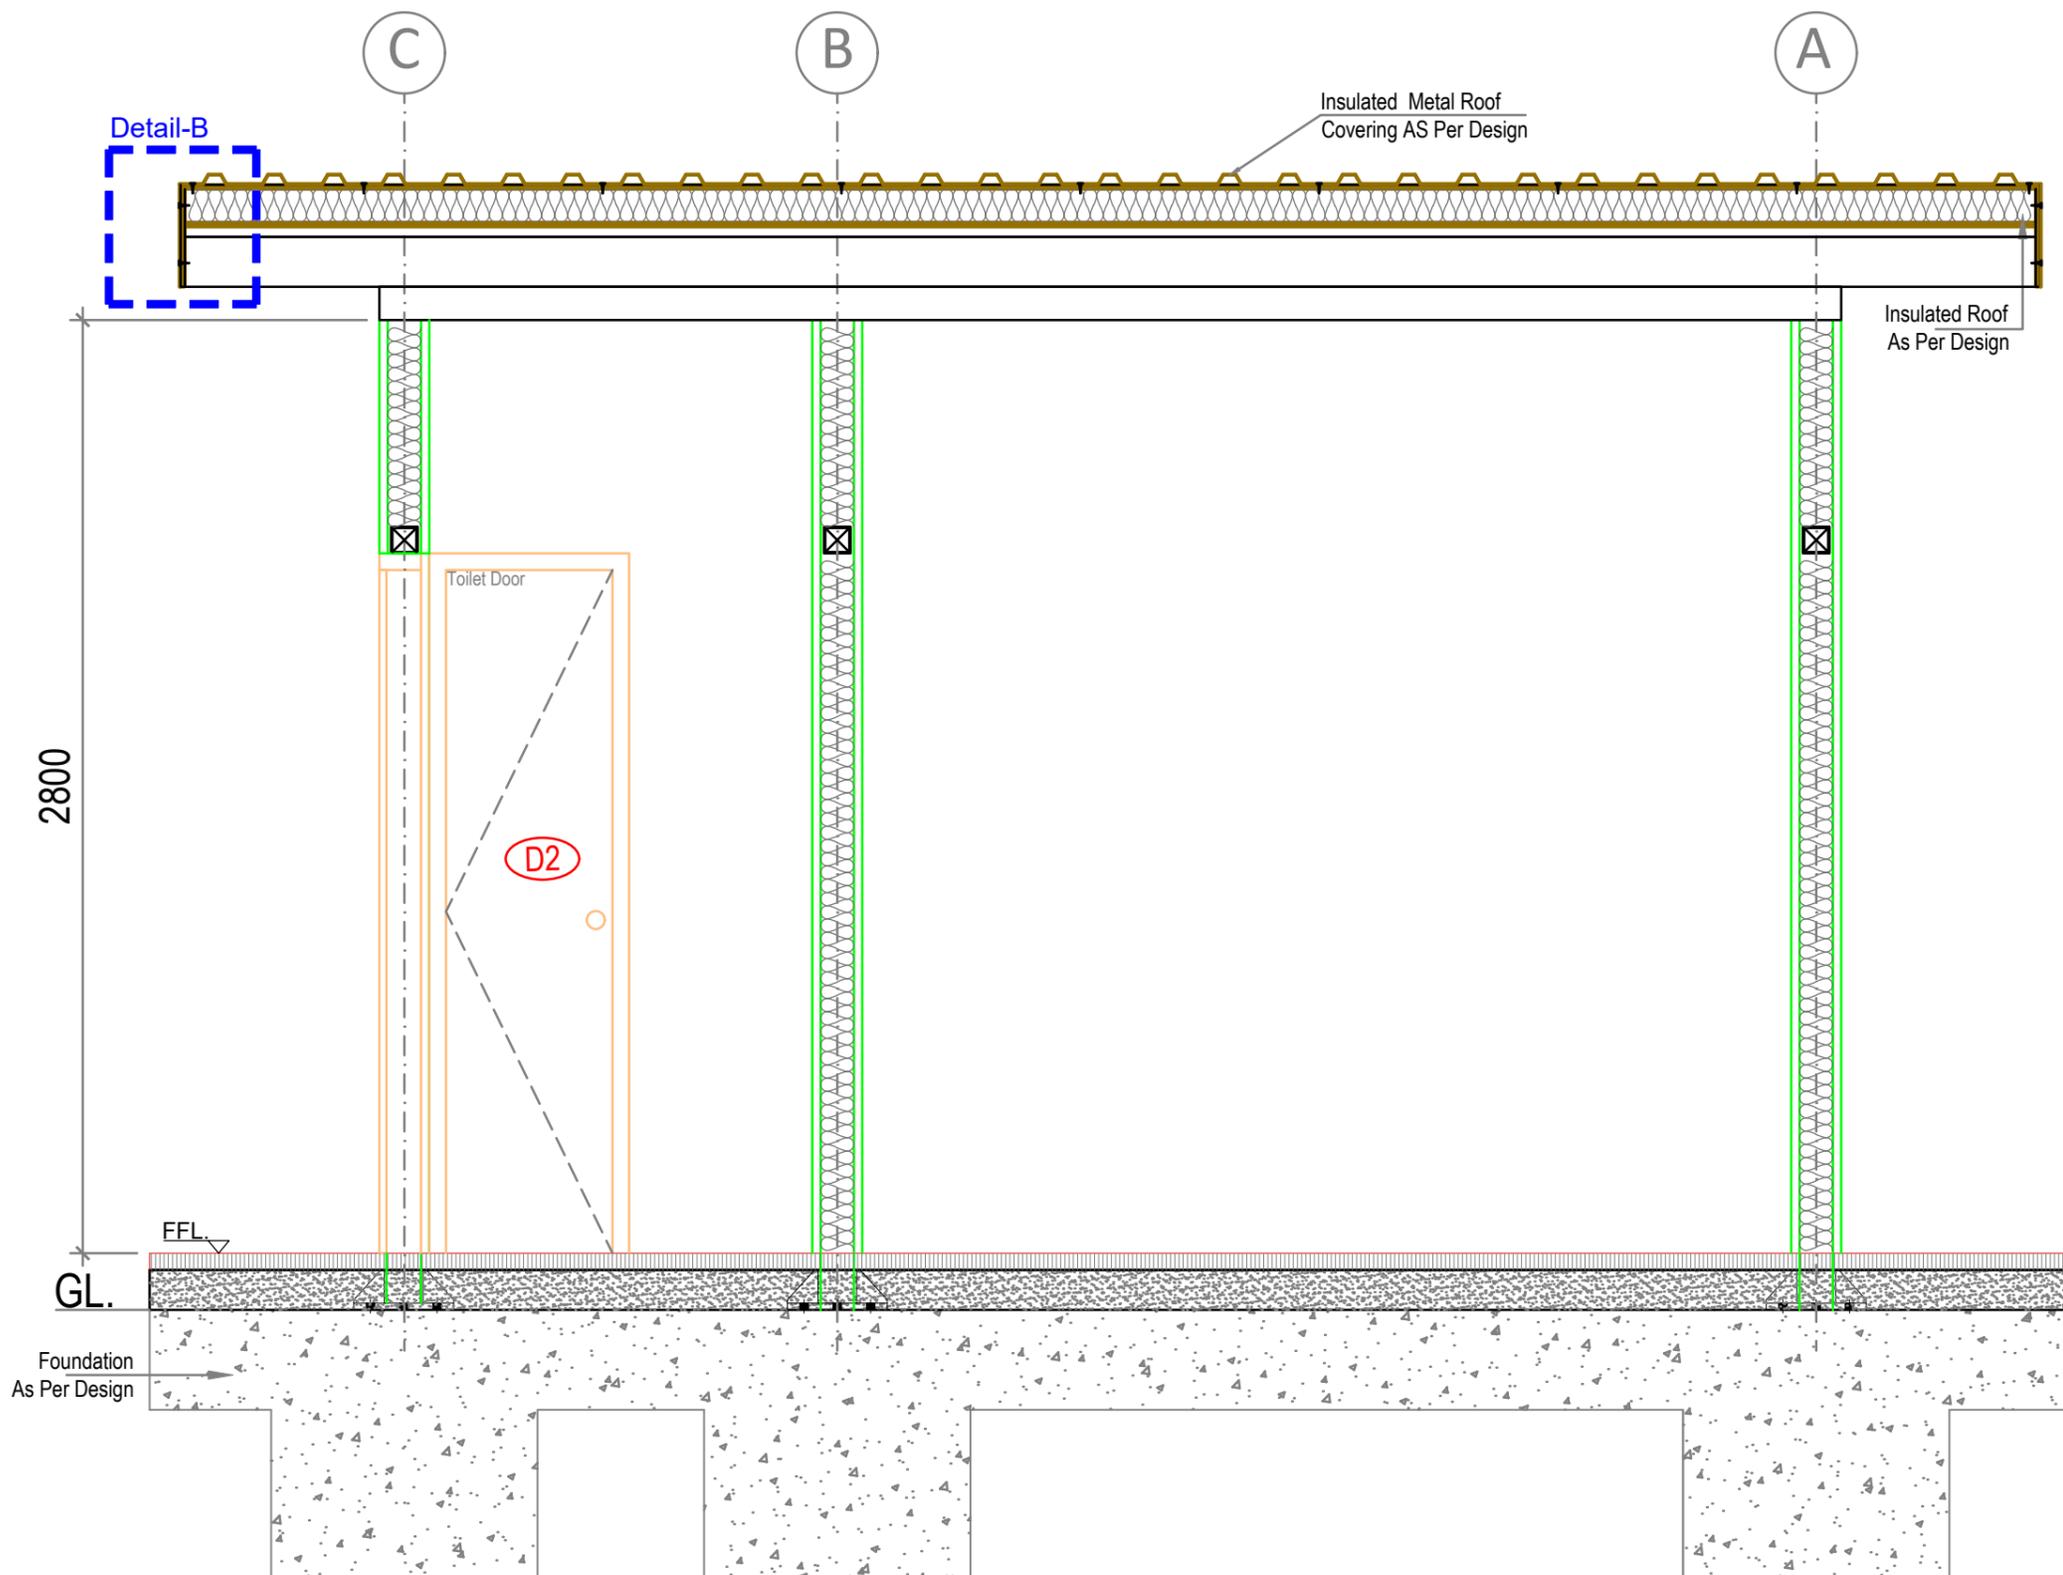

02 Section-C  
SCALE - 1:30

NOTE:  
THIS DRAWING IS A COPYRIGHT. IT IS THE PROPERTY OF STUDIO VANRO AND IS NOT TO BE REPRODUCED, COPIED, HANDED OVER TO A THIRD PARTY OR USED FOR ANY PURPOSE OTHER THAN THAT FOR WHICH IT HAS BEEN LOANED.


GENERAL NOTES:  
ALL DIMENSIONS INDICATED ARE IN MILLIMETER UNLESS MENTIONED OTHERWISE  
ALL DIMENSIONS ARE TO BE CROSS CHECKED AT SITE AND ANY DISCREPANCY SHALL BE BROUGHT TO NOTICE BEFORE EXECUTION.  
ALL SERVICE DRAWINGS SHALL BE READ IN CONJUNCTION WITH THIS DRAWING AND OTHER DETAILS, ANY DISCREPANCY WHATSOEVER SHALL BE BROUGHT TO NOTICE BEFORE EXECUTION.

S.NO	DATE	DRAWN	CHECKED	VERIFIED	REMARKS
01	22.01.2025	MP	VN	SD/SSG	RO_Drawing Drawn


REVISIONS	KEY PLAN




CLIENT	PROJECT	
J D Centre of Art	J D Centre of Art, Bhubaneshwar	
ARCHITECT	DRAWING	
Studio VanRO	SECURITY ROOM-SECTION-C	
STRUCTURAL CONSULTANT	SCALE	COMPUTER FILE
Mahendra Raj Consultants Pvt. Ltd	1:30 @ A3	JDCA- Security Room -20250204-MP
MUSEUM DESIGN	DRAWN BY	CHECKED BY
Siddhartha Das Studio	MAHESH PRAKASH	VIVEK NAMDEV
SANITARY, ELECTRICAL, HVAC, FIRE FIGHTING CONSULTANT	DATE	DRAWING TITLE
	22-01-2025	

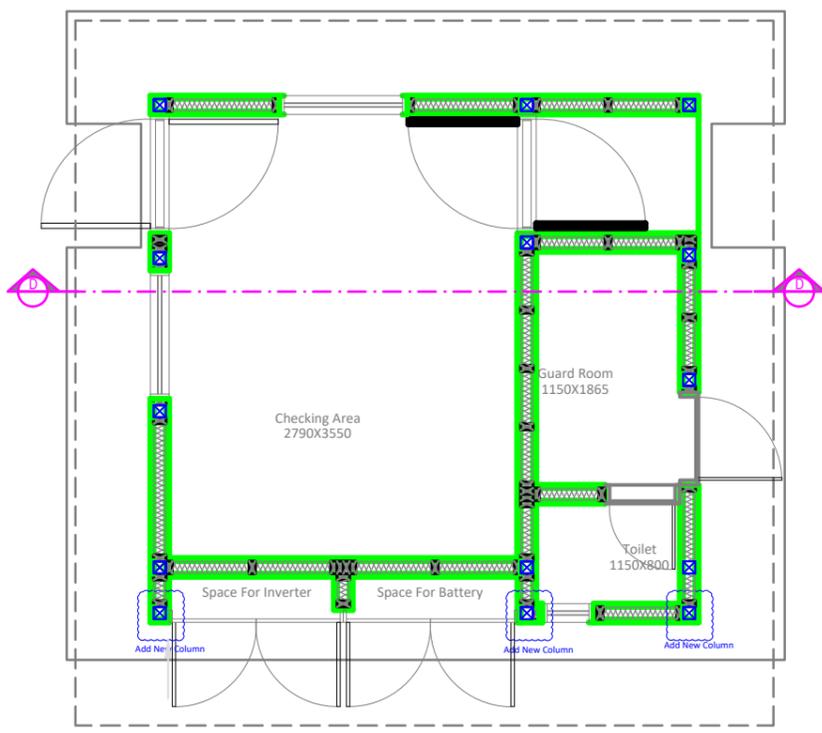

01 Key Plan  
SCALE - 1:80

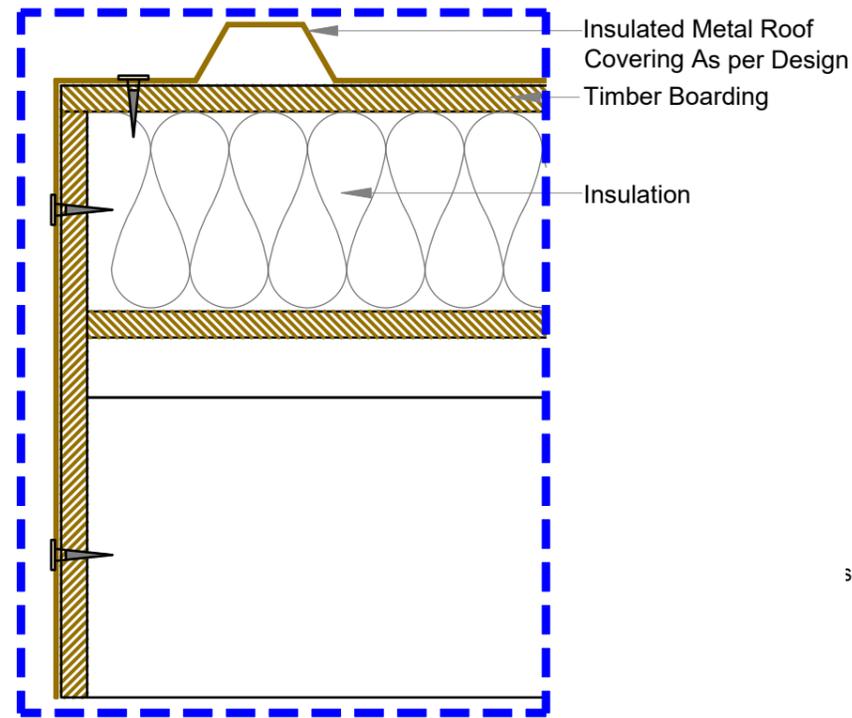

02 Detail-B  
SCALE - 1:5

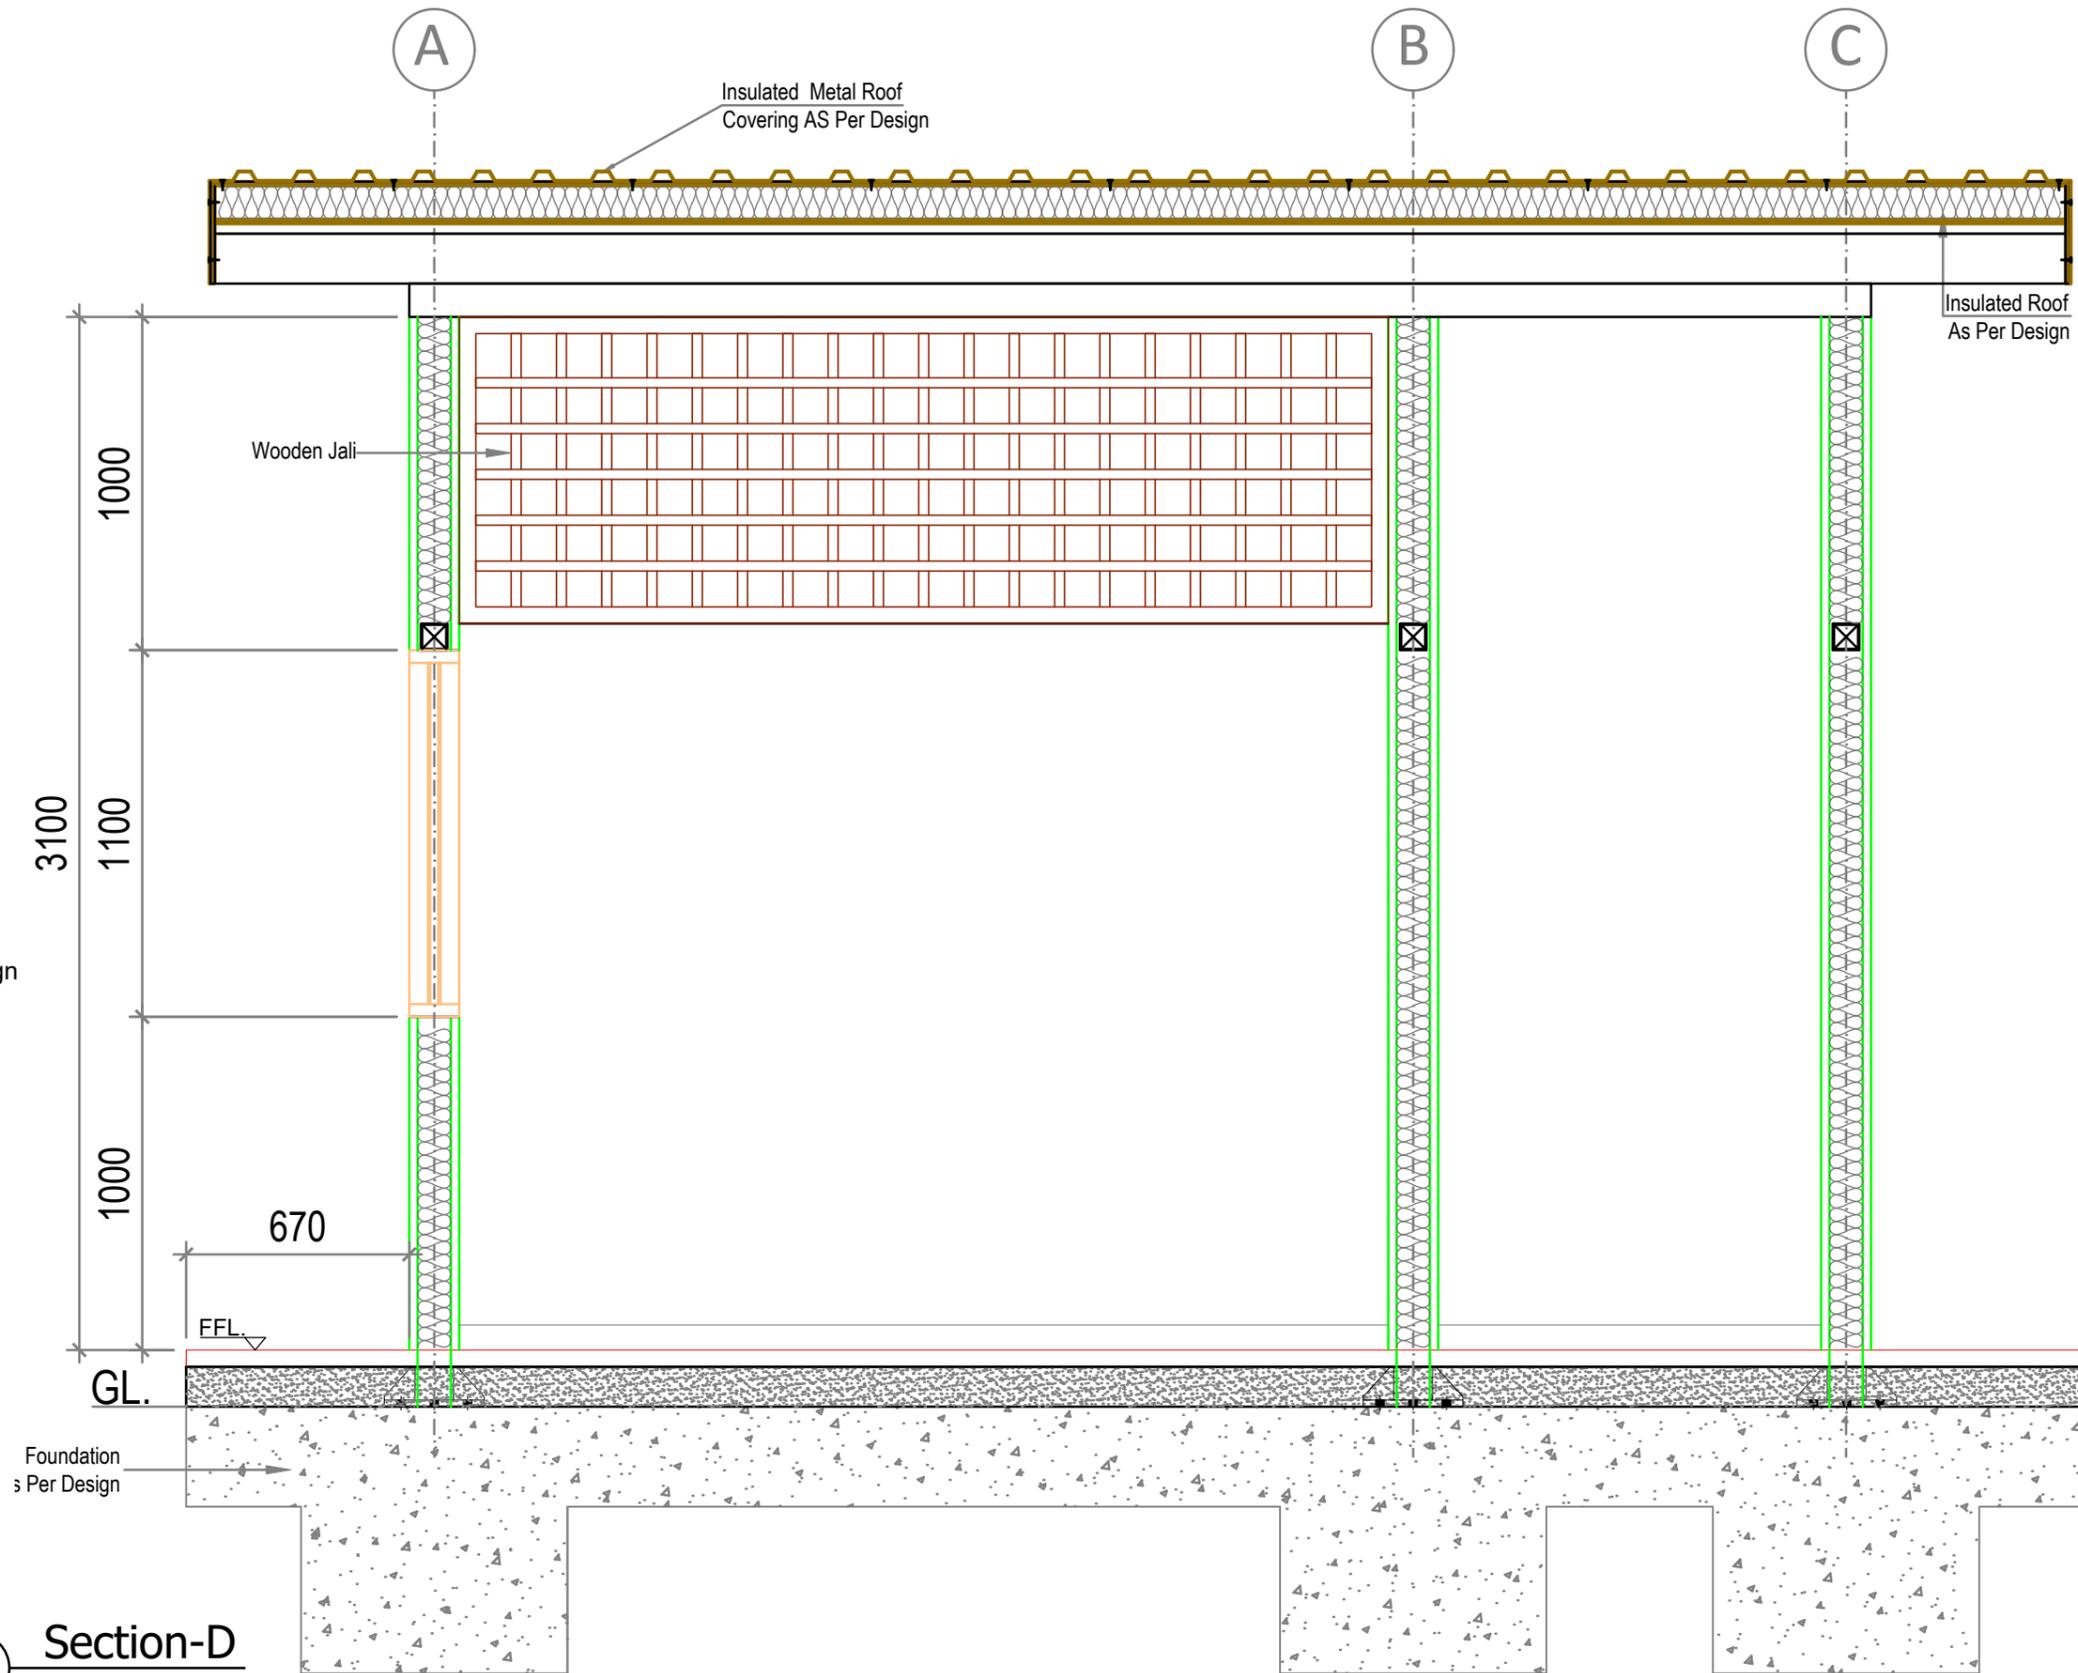


02 Section-D  
SCALE - 1:30


NOTE:  
THIS DRAWING IS A COPYRIGHT. IT IS THE PROPERTY OF STUDIO VANRO AND IS NOT TO BE REPRODUCED, COPIED, HANDED OVER TO A THIRD PARTY OR USED FOR ANY PURPOSE OTHER THAN THAT FOR WHICH IT HAS BEEN LOANED.

GENERAL NOTES:  
ALL DIMENSIONS INDICATED ARE IN MILLIMETER UNLESS MENTIONED OTHERWISE  
ALL DIMENSIONS ARE TO BE CROSS CHECKED AT SITE AND ANY DISCREPANCY SHALL BE BROUGHT TO NOTICE BEFORE EXECUTION.  
ALL SERVICE DRAWINGS SHALL BE READ IN CONJUNCTION WITH THIS DRAWING AND OTHER DETAILS, ANY DISCREPANCY WHATSOEVER SHALL BE BROUGHT TO NOTICE BEFORE EXECUTION.


S.NO	DATE	DRAWN	CHECKED	VERIFIED	REMARKS
01	22.01.2025	MP	VN	SD/SSG	RO_Drawing Drawn

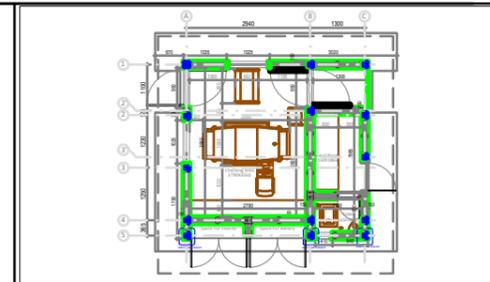

CLIENT	J D Centre of Art		PROJECT	J D Centre of Art, Bhubaneswar	
ARCHITECT	Studio VanRO		DRAWING	SECURITY ROOM-COMPUTER-D	
STRUCTURAL CONSULTANT	Mahendra Raj Consultants Pvt. Ltd	SCALE	1:30 @ A3	COMPUTER FILE	JDCA- Security Room -20250204-MP
MUSEUM DESIGN	Siddhartha Das Studio	DRAWN BY	MAHESH PRAKASH	CHECKED BY	VIVEK NAMDEV
SANITARY, ELECTRICAL, HVAC, FIRE FIGHTING CONSULTANT		DATE	22-01-2025	DRAWING TITLE	

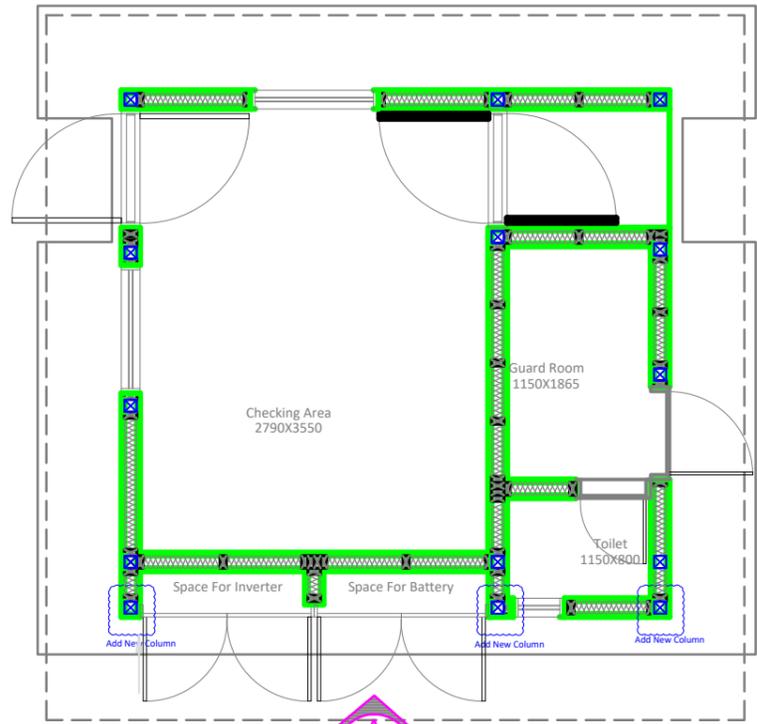

01 Plan  
SCALE - 1:80

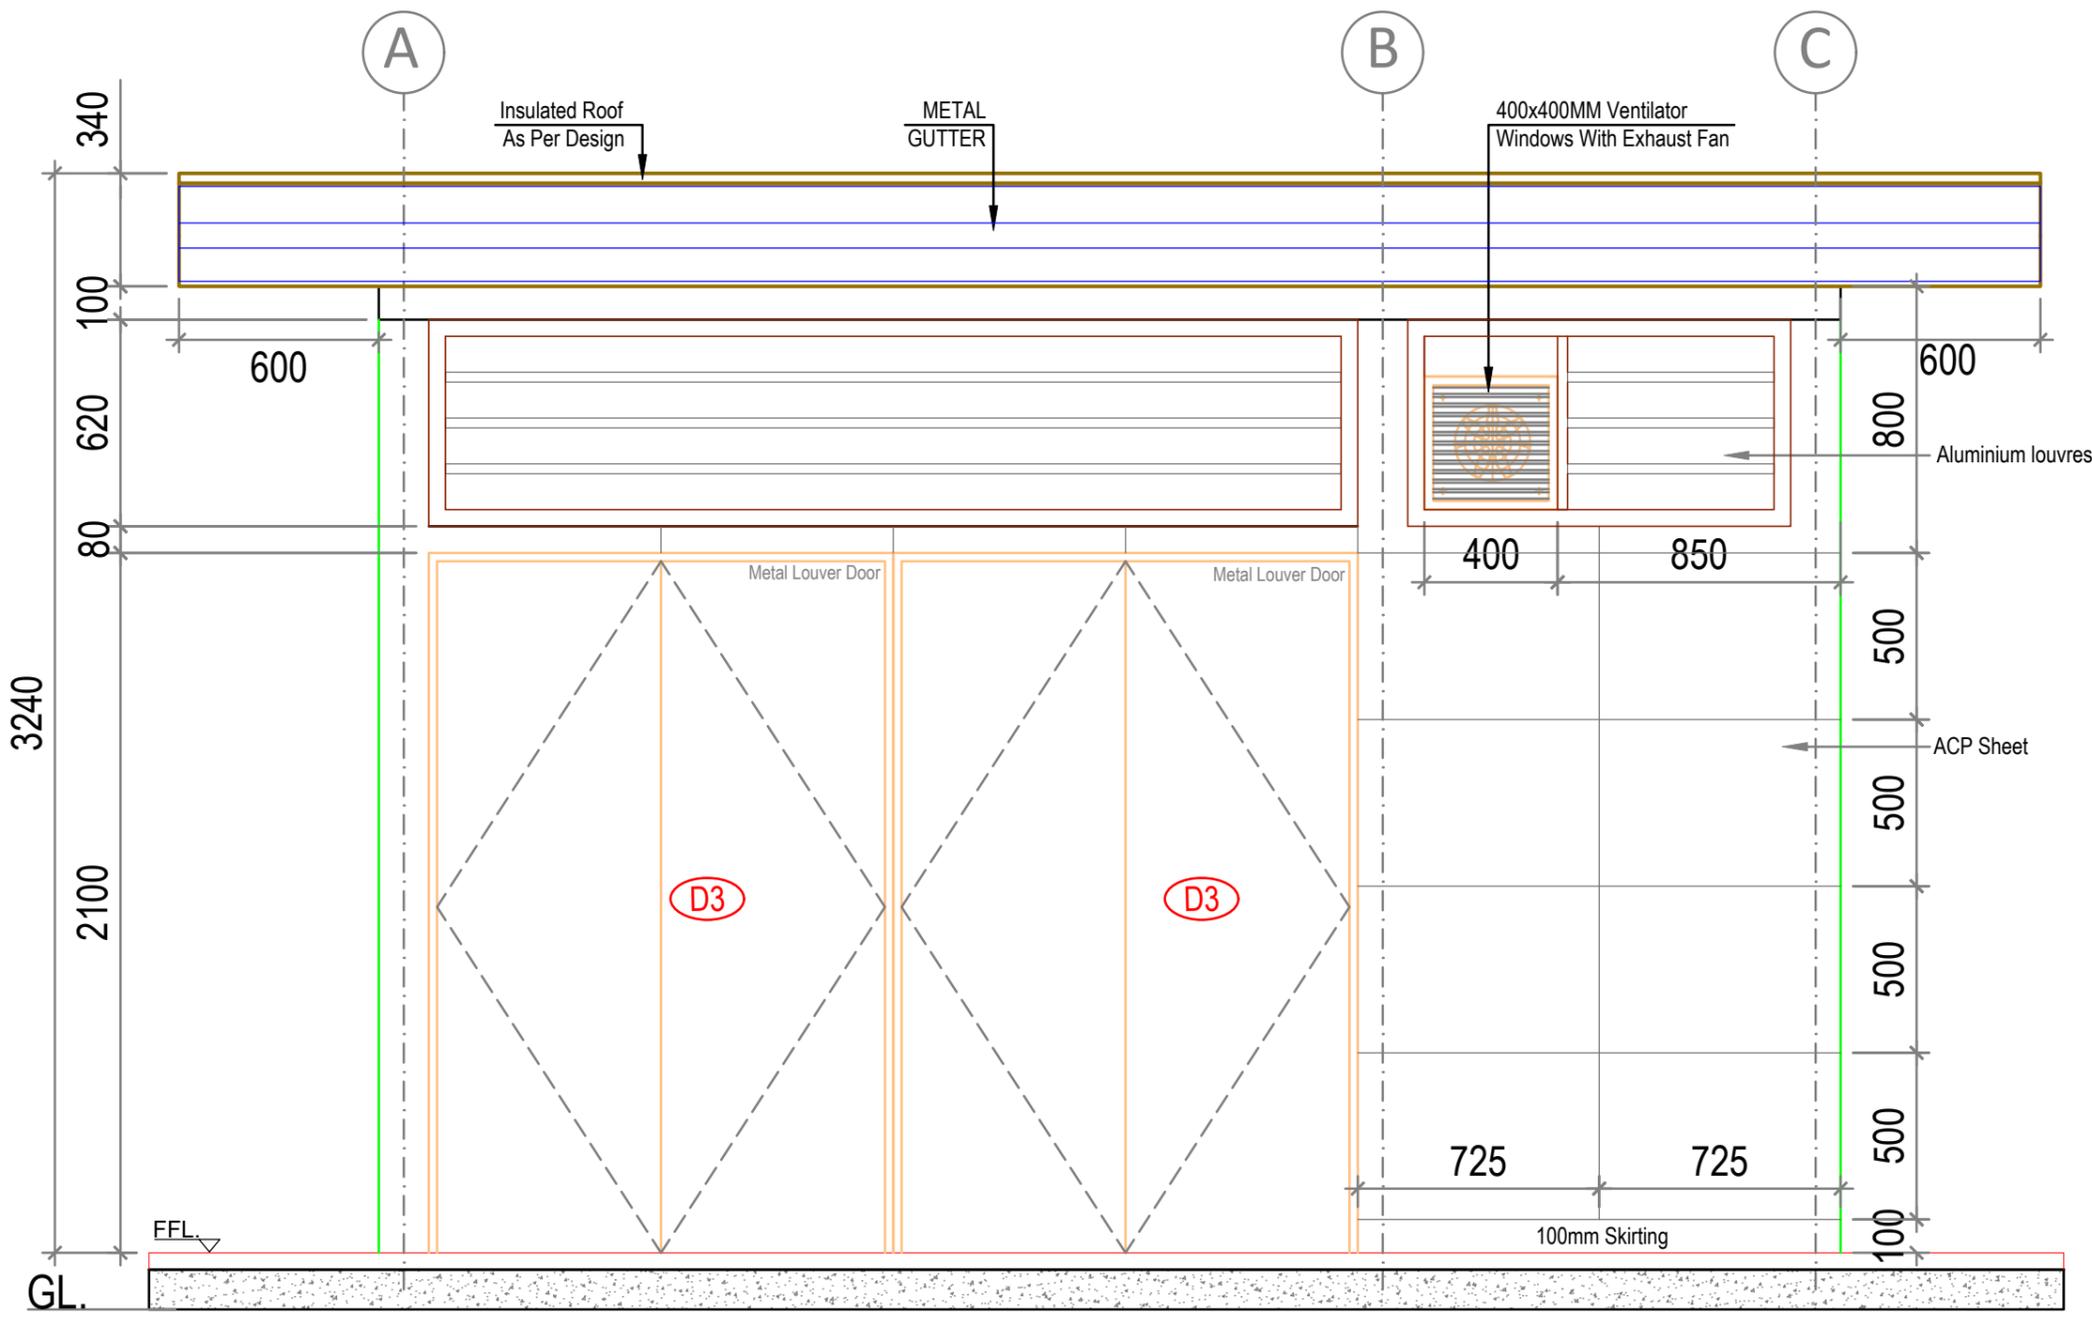


02 Elevations -A  
SCALE - 1:30


NOTE:  
THIS DRAWING IS A COPYRIGHT. IT IS THE PROPERTY OF STUDIO VANRO AND IS NOT TO BE REPRODUCED, COPIED, HANDED OVER TO A THIRD PARTY OR USED FOR ANY PURPOSE OTHER THAN THAT FOR WHICH IT HAS BEEN LOANED.

GENERAL NOTES:  
ALL DIMENSIONS INDICATED ARE IN MILLIMETER UNLESS MENTIONED OTHERWISE  
ALL DIMENSIONS ARE TO BE CROSS CHECKED AT SITE AND ANY DISCREPANCY SHALL BE BROUGHT TO NOTICE BEFORE EXECUTION.  
ALL SERVICE DRAWINGS SHALL BE READ IN CONJUNCTION WITH THIS DRAWING AND OTHER DETAILS, ANY DISCREPANCY WHATSOEVER SHALL BE BROUGHT TO NOTICE BEFORE EXECUTION.


S.NO	DATE	DRAWN	CHECKED	VERIFIED	REMARKS
01	22.01.2025	MP	VN	SD/SSG	RO_Drawing Drawn

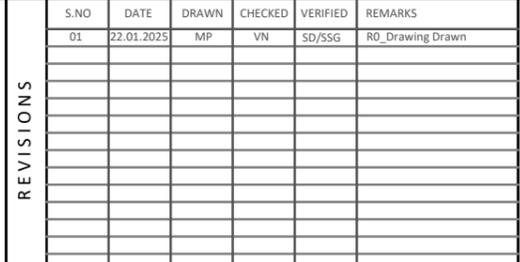

CLIENT	J D Centre of Art	PROJECT	J D Centre of Art, Bhubaneswar
ARCHITECT	Studio VanRO	DRAWING	SECURITY ROOM- ELEVATION-A
STRUCTURAL CONSULTANT	Mahendra Raj Consultants Pvt. Ltd	SCALE	1:30 @ A3
MUSEUM DESIGN	Siddhartha Das Studio	COMPUTER FILE	JDCA- Security Room -20250204-MP
SANITARY, ELECTRICAL, HVAC, FIRE FIGHTING CONSULTANT		DRAWN BY	MAHESH PRAKASH
		CHECKED BY	VIVEK NAMDEV
		DATE	22-01-2025
		DRAWING TITLE	

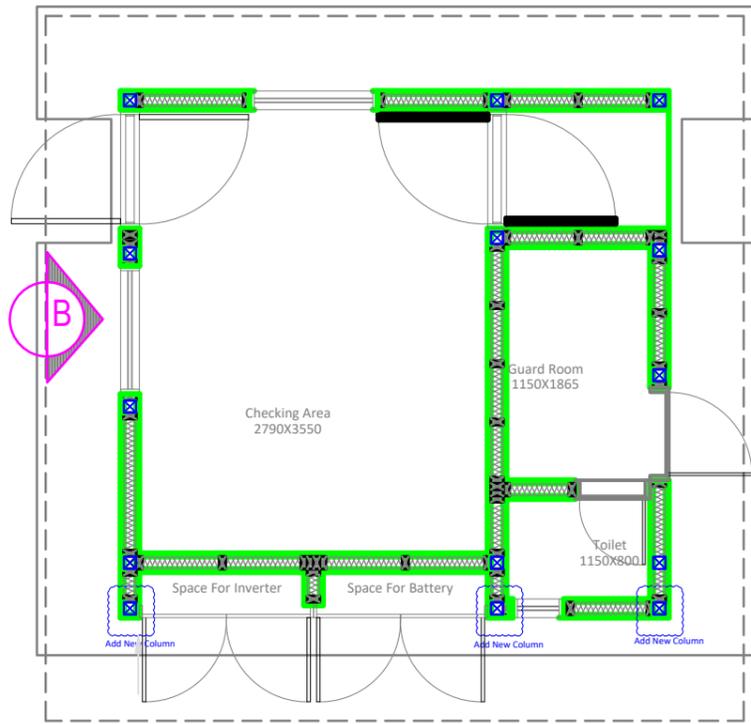

01 Plan  
SCALE - 1:80

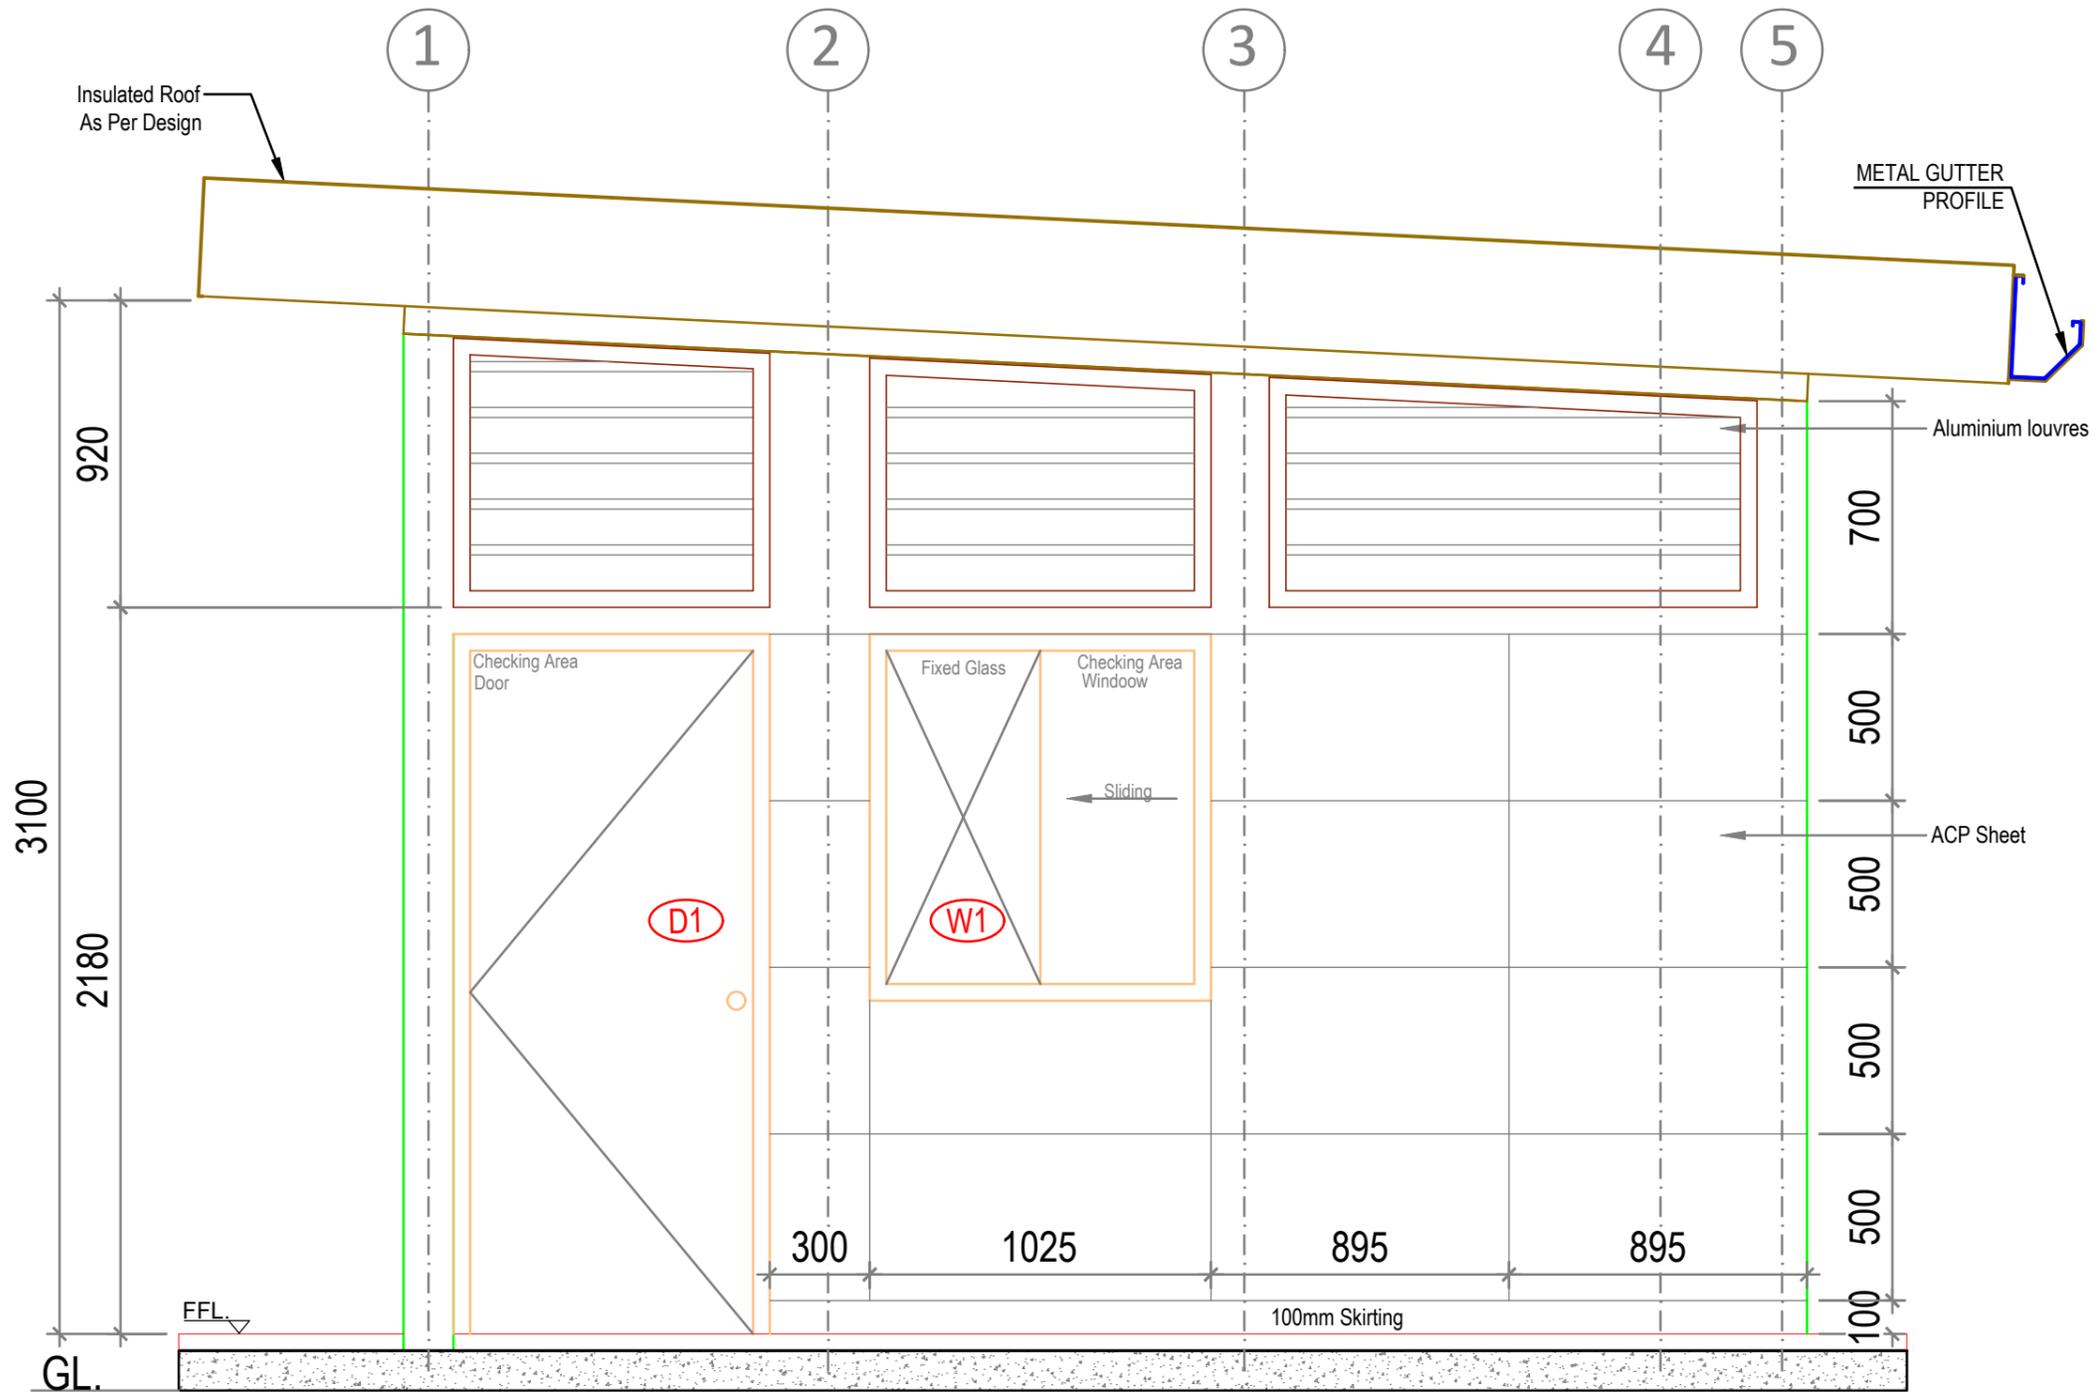


02 Elevation-B  
SCALE - 1:30

NOTE:  
THIS DRAWING IS A COPYRIGHT. IT IS THE PROPERTY OF STUDIO VANRO AND IS NOT TO BE REPRODUCED, COPIED, HANDED OVER TO A THIRD PARTY OR USED FOR ANY PURPOSE OTHER THAN THAT FOR WHICH IT HAS BEEN LOANED.


GENERAL NOTES:  
ALL DIMENSIONS INDICATED ARE IN MILLIMETER UNLESS MENTIONED OTHERWISE  
ALL DIMENSIONS ARE TO BE CROSS CHECKED AT SITE AND ANY DISCREPANCY SHALL BE BROUGHT TO NOTICE BEFORE EXECUTION.

ALL SERVICE DRAWINGS SHALL BE READ IN CONJUNCTION WITH THIS DRAWING AND OTHER DETAILS, ANY DISCREPANCY WHATSOEVER SHALL BE BROUGHT TO NOTICE BEFORE EXECUTION.


S.NO	DATE	DRAWN	CHECKED	VERIFIED	REMARKS
01	22.01.2025	MP	VN	SD/SSG	RO_Drawing Drawn

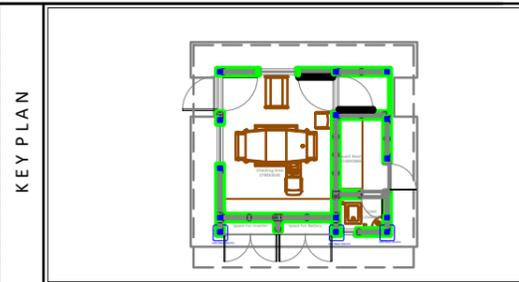

CLIENT		PROJECT	
J D Centre of Art		J D Centre of Art, Bhubaneswar	
ARCHITECT		DRAWING	
Studio VanRO		SECURITY ROOM- ELEVATION-B	
STRUCTURAL CONSULTANT		SCALE	COMPUTER FILE
Mahendra Raj Consultants Pvt. Ltd		1:30 @ A3	JOCA- Security Room -20250204-MP
MUSEUM DESIGN		DRAWN BY	CHECKED BY
Siddhartha Das Studio		MAHESH PRAKASH	VIVEK NAMDEV
SANITARY, ELECTRICAL, HVAC, FIRE FIGHTING CONSULTANT		DATE	DRAWING TITLE
		22-01-2025	

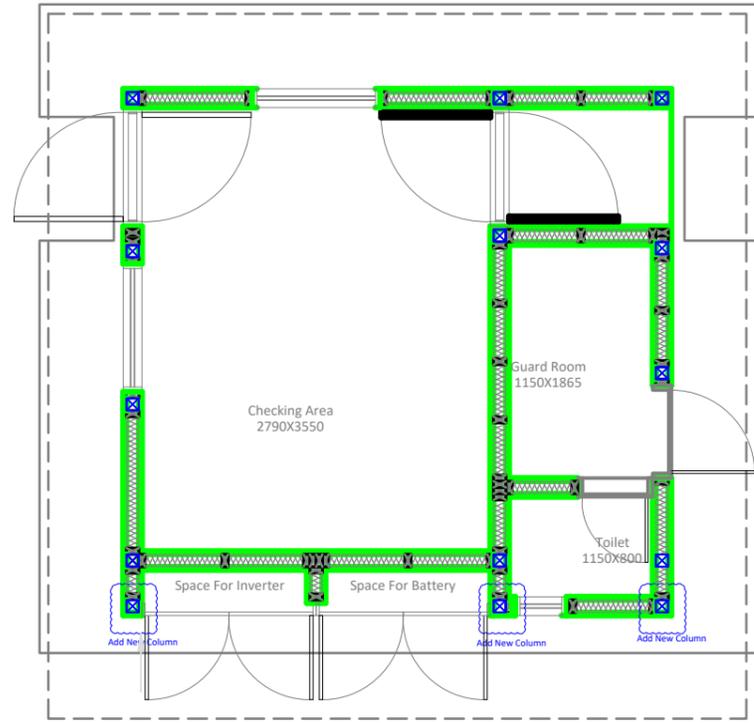

01 Plan  
SCALE - 1:80

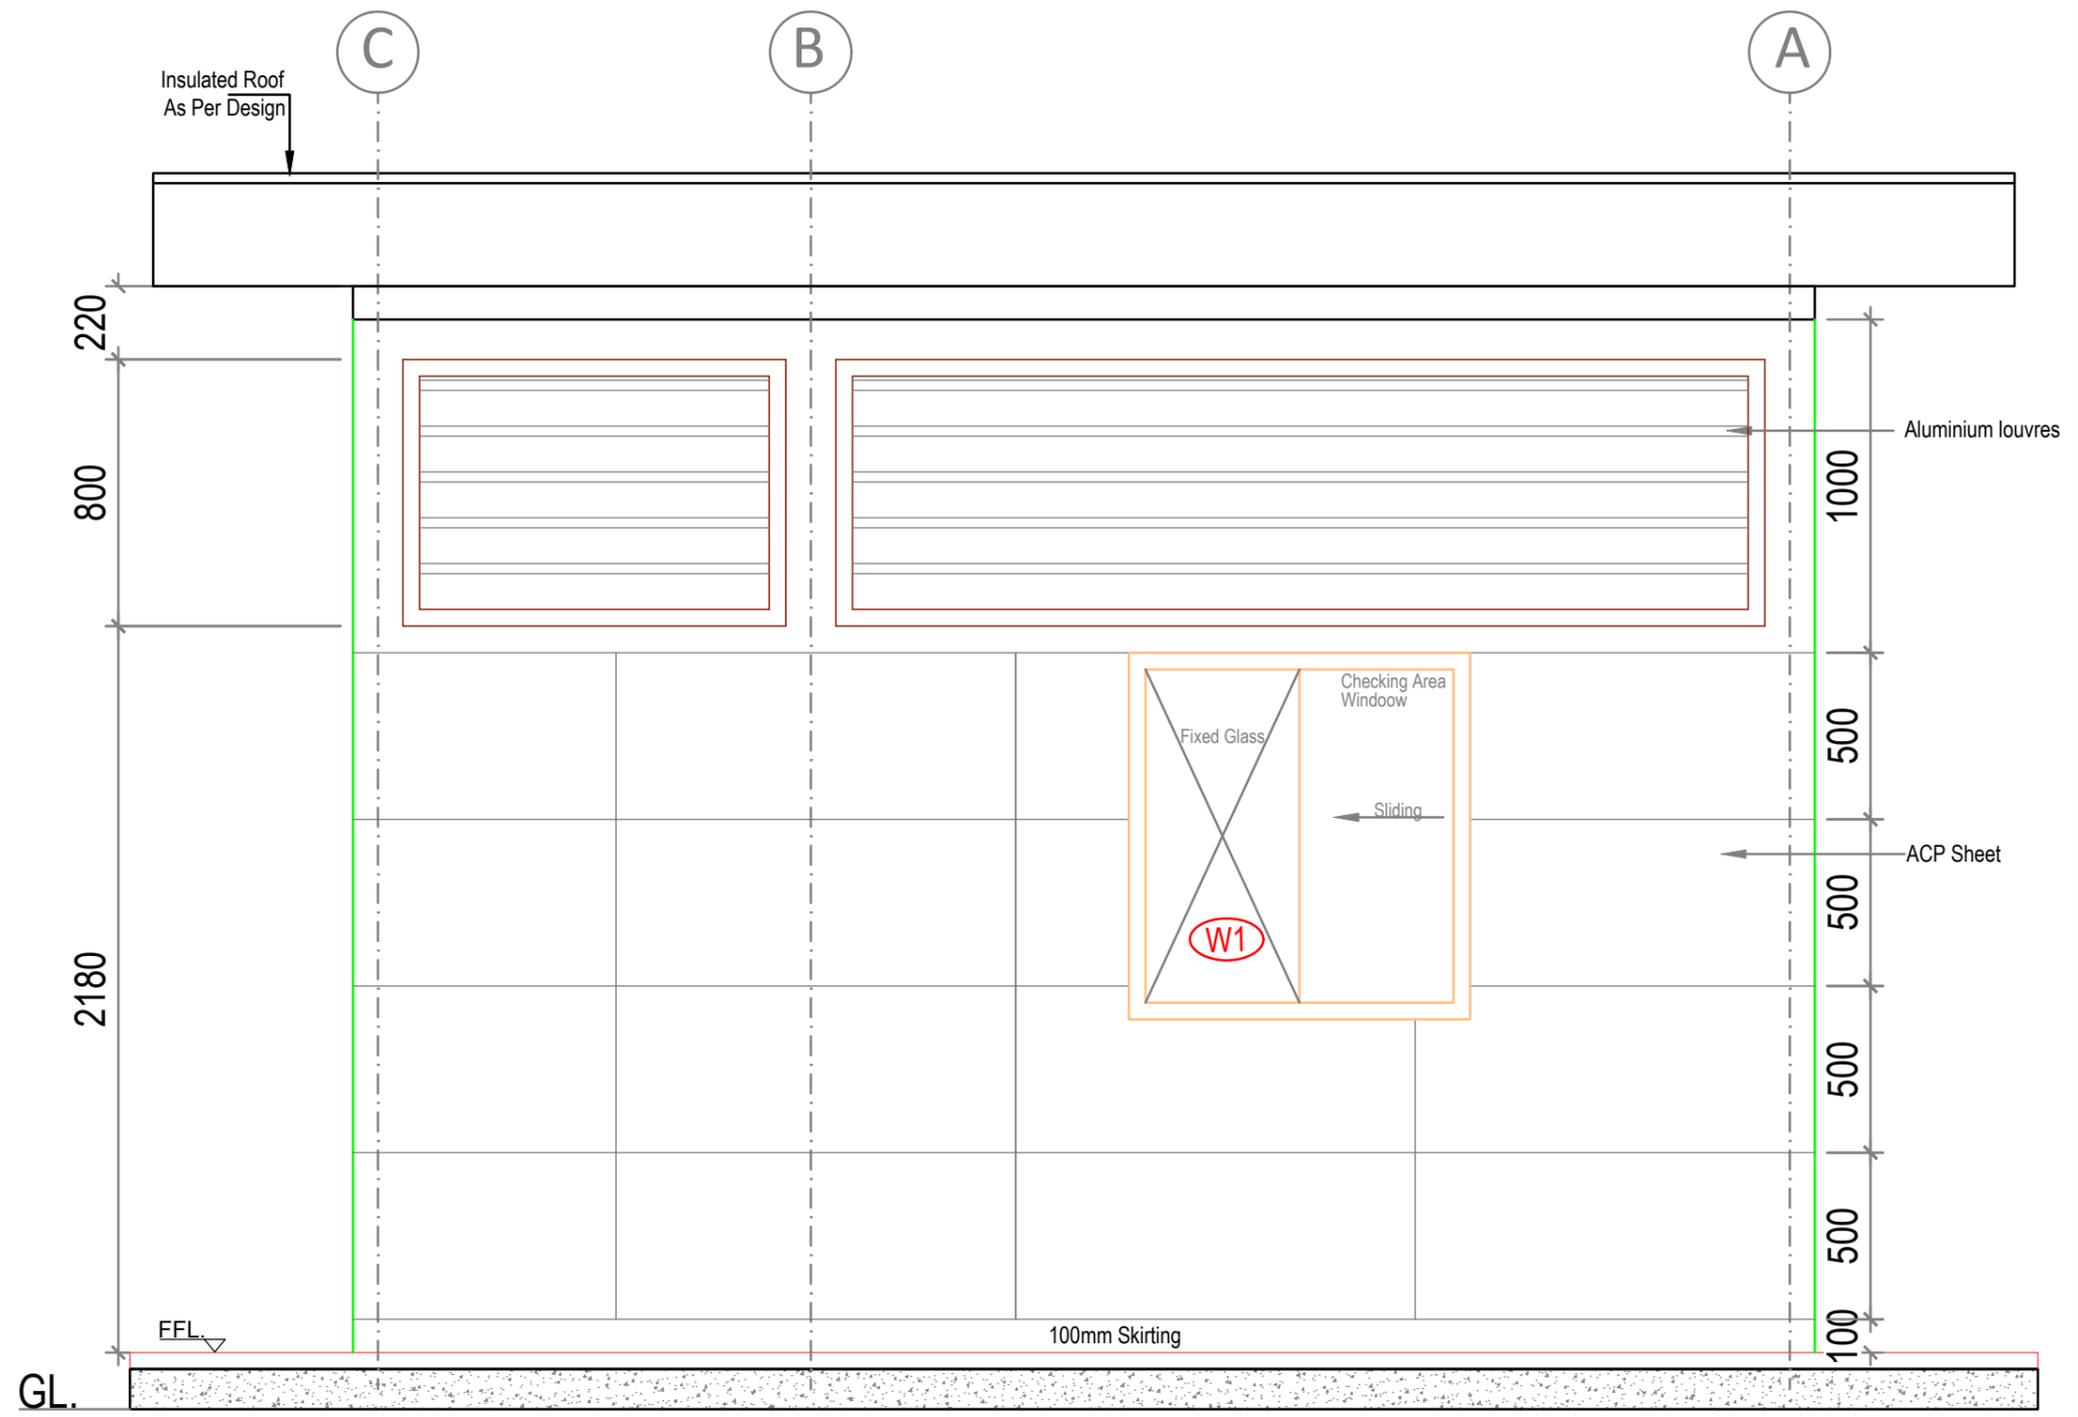


02 Elevation-C  
SCALE - 1:30


NOTE:  
THIS DRAWING IS A COPYRIGHT. IT IS THE PROPERTY OF STUDIO VANRO AND IS NOT TO BE REPRODUCED, COPIED, HANDED OVER TO A THIRD PARTY OR USED FOR ANY PURPOSE OTHER THAN THAT FOR WHICH IT HAS BEEN LOANED.

GENERAL NOTES:  
ALL DIMENSIONS INDICATED ARE IN MILLIMETER UNLESS MENTIONED OTHERWISE  
ALL DIMENSIONS ARE TO BE CROSS CHECKED AT SITE AND ANY DISCREPANCY SHALL BE BROUGHT TO NOTICE BEFORE EXECUTION.  
ALL SERVICE DRAWINGS SHALL BE READ IN CONJUNCTION WITH THIS DRAWING AND OTHER DETAILS, ANY DISCREPANCY WHATSOEVER SHALL BE BROUGHT TO NOTICE BEFORE EXECUTION.


S.NO	DATE	DRAWN	CHECKED	VERIFIED	REMARKS
01	22.01.2025	MP	VN	SD/SSG	RO_Drawing Drawn

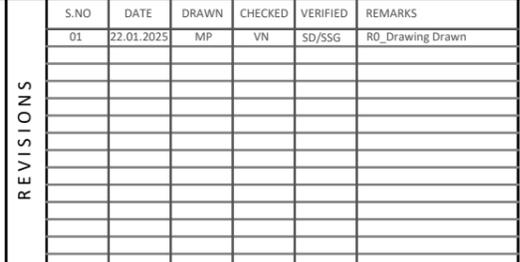

CLIENT	PROJECT	
J D Centre of Art	J D Centre of Art, Bhubaneshwar	
ARCHITECT	DRAWING	
Studio VanRO	SECURITY ROOM- ELEVATION-C	
STRUCTURAL CONSULTANT	SCALE	COMPUTER FILE
Mahendra Raj Consultants Pvt. Ltd	1:30 @ A3	JDCA- Security Room -20250204-MP
MUSEUM DESIGN	DRAWN BY	CHECKED BY
Siddhartha Das Studio	MAHESH PRAKASH	VIVEK NAMDEV
SANITARY, ELECTRICAL, HVAC, FIRE FIGHTING CONSULTANT	DATE	DRAWING TITLE
	22-01-2025	

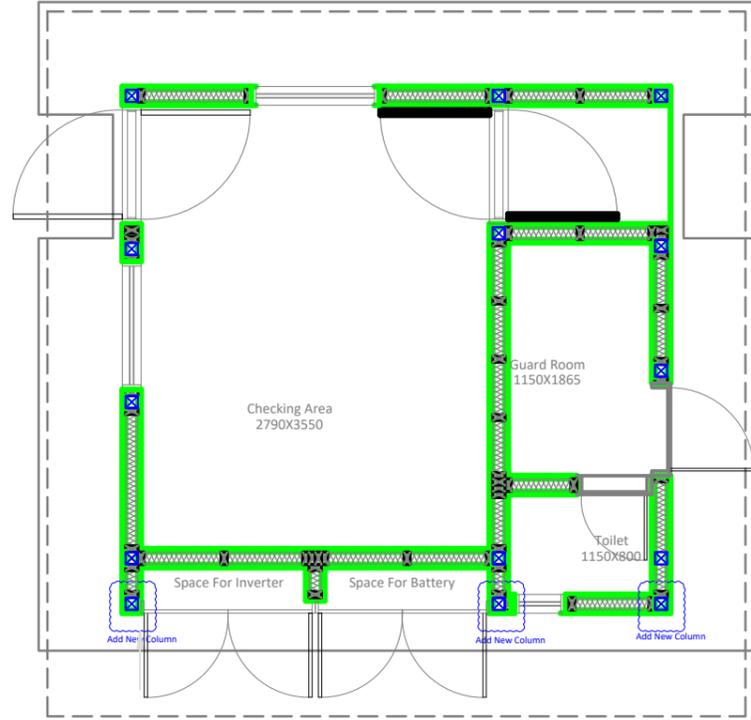

01 Plan  
SCALE - 1:80

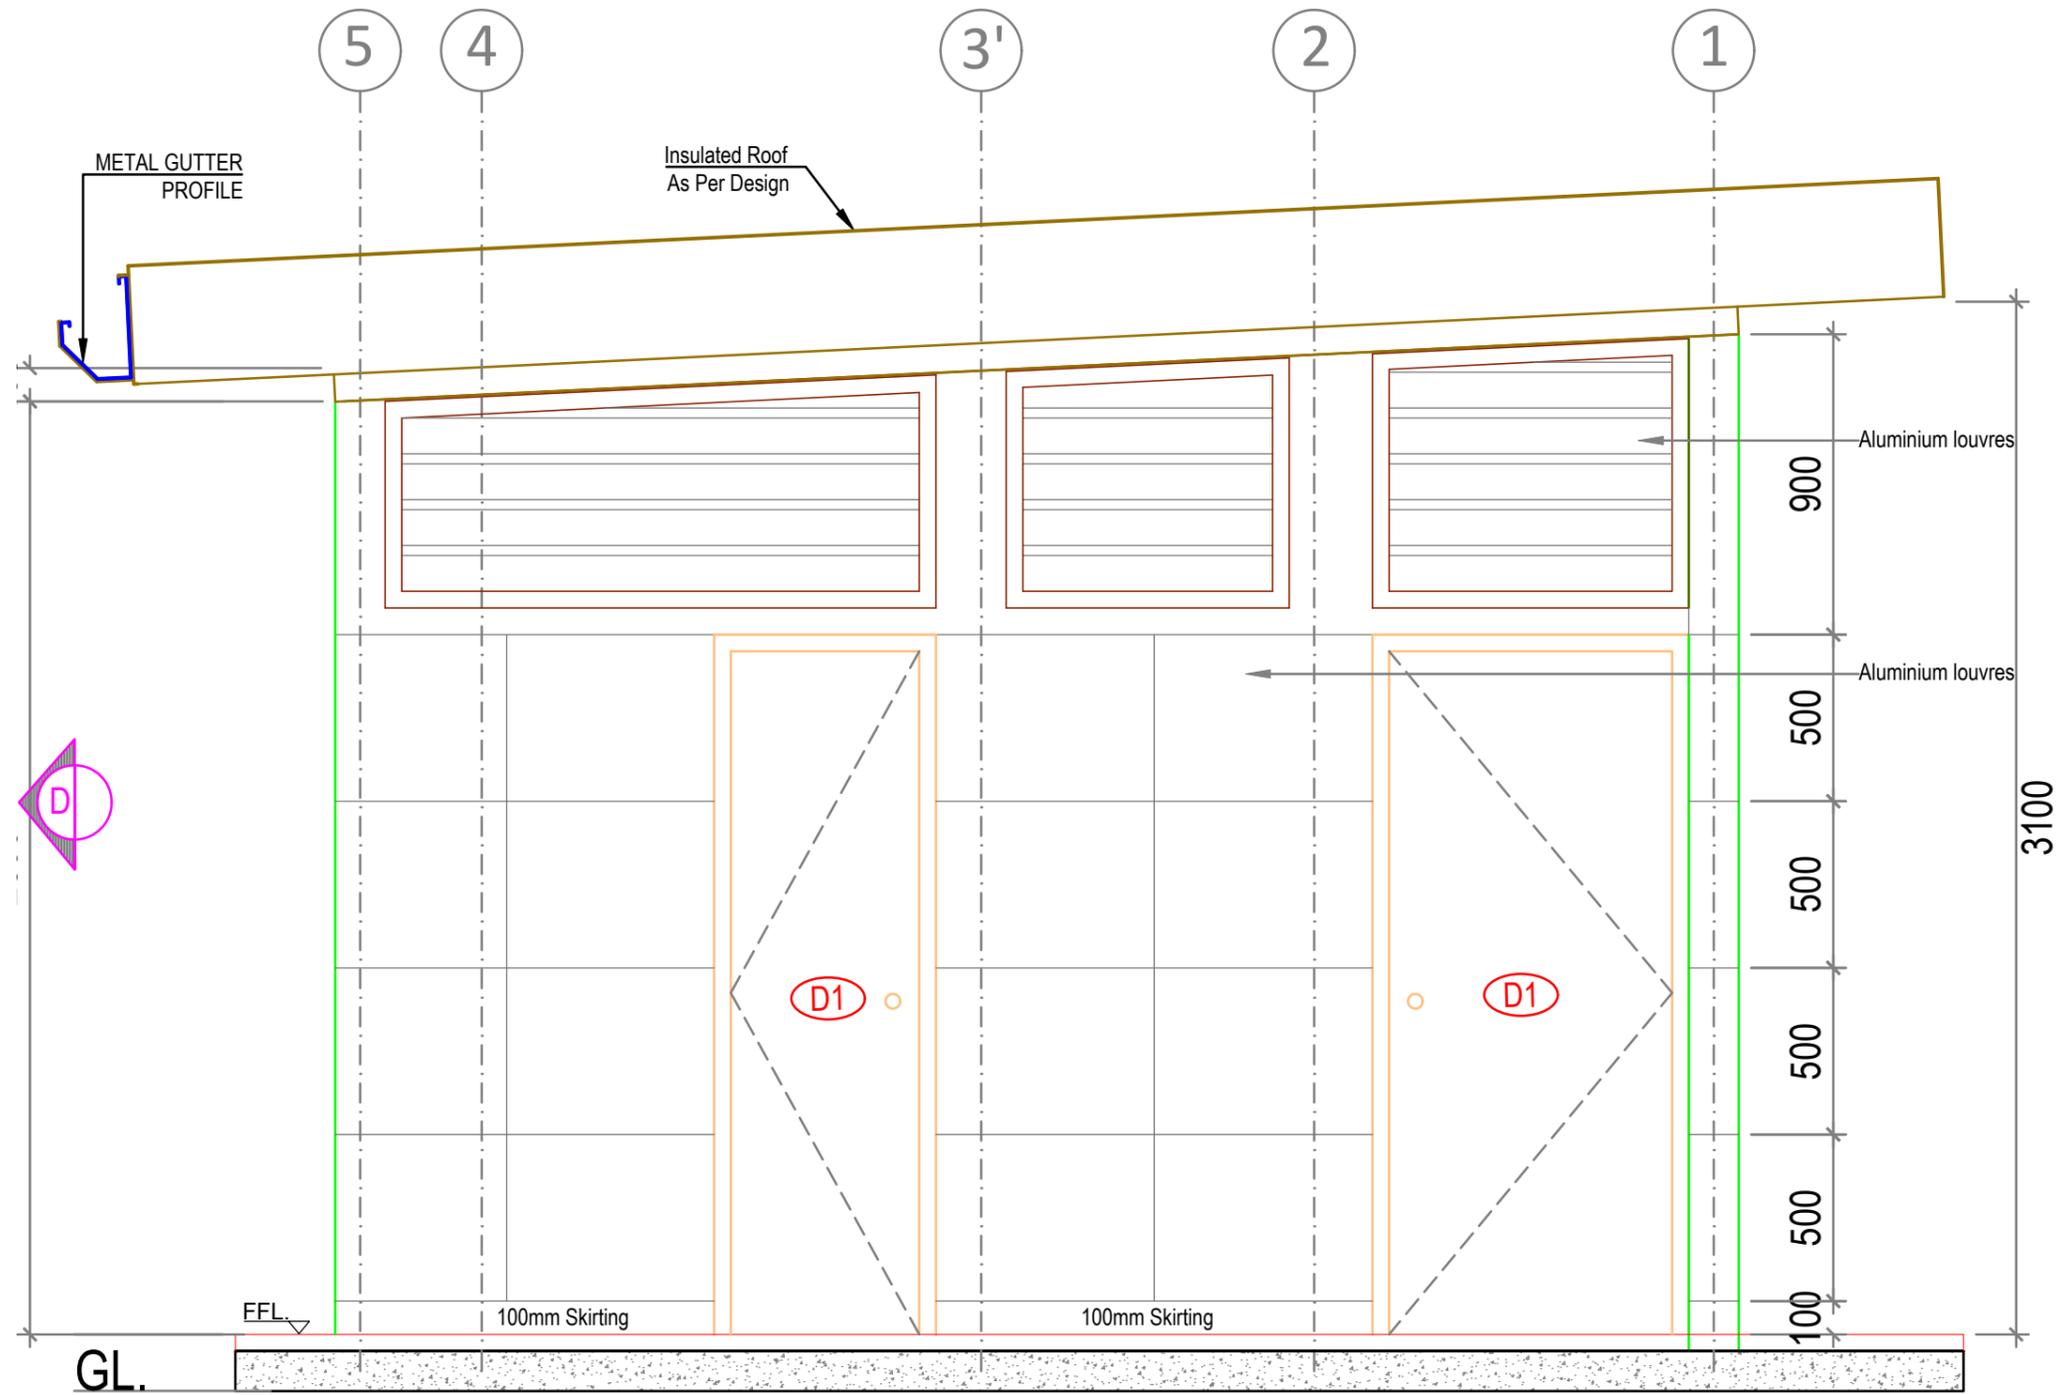


02 Elevation-D  
SCALE - 1:30

NOTE:  
THIS DRAWING IS A COPYRIGHT. IT IS THE PROPERTY OF STUDIO VANRO AND IS NOT TO BE REPRODUCED, COPIED, HANDED OVER TO A THIRD PARTY OR USED FOR ANY PURPOSE OTHER THAN THAT FOR WHICH IT HAS BEEN LOANED.

GENERAL NOTES:  
ALL DIMENSIONS INDICATED ARE IN MILLIMETER UNLESS MENTIONED OTHERWISE  
ALL DIMENSIONS ARE TO BE CROSS CHECKED AT SITE AND ANY DISCREPANCY SHALL BE BROUGHT TO NOTICE BEFORE EXECUTION.  
ALL SERVICE DRAWINGS SHALL BE READ IN CONJUNCTION WITH THIS DRAWING AND OTHER DETAILS, ANY DISCREPANCY WHATSOEVER SHALL BE BROUGHT TO NOTICE BEFORE EXECUTION.

S.NO	DATE	DRAWN	CHECKED	VERIFIED	REMARKS
01	22.01.2025	MP	VN	SD/SSG	RO_Drawing Drawn

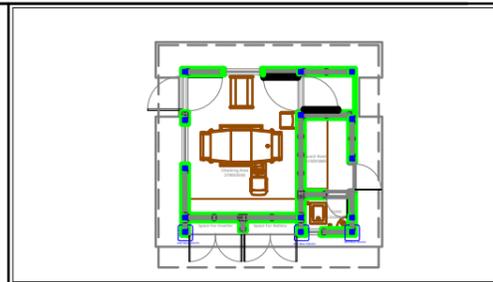

CLIENT		PROJECT	
J D Centre of Art		J D Centre of Art, Bhubaneswar	
ARCHITECT		DRAWING	
Studio VanRO		SECURITY ROOM- ELEVATION-D	
STRUCTURAL CONSULTANT		SCALE	COMPUTER FILE
Mahendra Raj Consultants Pvt. Ltd		1:30 @ A3	JDCA- Security Room -20250204-MP
MUSEUM DESIGN		DRAWN BY	CHECKED BY
Siddhartha Das Studio		MAHESH PRAKASH	VIVEK NAMDEV
SANITARY, ELECTRICAL, HVAC, FIRE FIGHTING CONSULTANT		DATE	DRAWING TITLE
		22-01-2025	

2950

3040

3040

2950

FFL

Bed

Bed

Guard Room Door

Toilet Door

D2

D2

Bed

01 Elevations -1  
SCALE - 1:25


02 Elevations -2  
SCALE - 1:25

03 Elevations -3  
SCALE - 1:25

04 Elevations -4  
SCALE - 1:25

01 Elevations -1  
SCALE - 1:25

05 Part Plan  
SCALE - 1:50

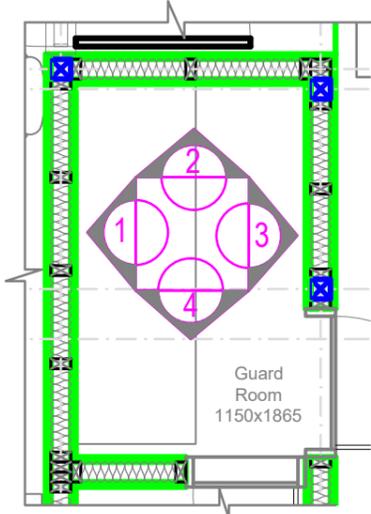


NOTE:  
THIS DRAWING IS A COPYRIGHT. IT IS THE PROPERTY OF STUDIO VANRO AND IS NOT TO BE REPRODUCED, COPIED, HANDED OVER TO A THIRD PARTY OR USED FOR ANY PURPOSE OTHER THAN THAT FOR WHICH IT HAS BEEN LOANED.


GENERAL NOTES:  
ALL DIMENSIONS INDICATED ARE IN MILLIMETER UNLESS MENTIONED OTHERWISE  
ALL DIMENSIONS ARE TO BE CROSS CHECKED AT SITE AND ANY DISCREPANCY SHALL BE BROUGHT TO NOTICE BEFORE EXECUTION.

ALL SERVICE DRAWINGS SHALL BE READ IN CONJUNCTION WITH THIS DRAWING AND OTHER DETAILS, ANY DISCREPANCY WHATSOEVER SHALL BE BROUGHT TO NOTICE BEFORE EXECUTION.


S.NO	DATE	DRAWN	CHECKED	VERIFIED	REMARKS
01	22.01.2025	MP	VN	SD/SSG	RO_Drawing Drawn

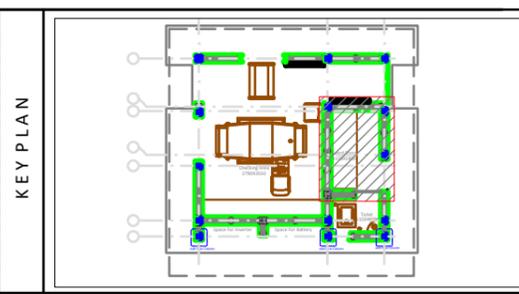


CLIENT		PROJECT	
J D Centre of Art		J D Centre of Art, Bhubaneswar	
ARCHITECT		DRAWING	
Studio VanRO		SECURITY ROOM- ELEVATIONS	
STRUCTURAL CONSULTANT		SCALE	COMPUTER FILE
Mahendra Raj Consultants Pvt. Ltd		1:25 @ A3	JDA- Security Room -20250204-MP
MUSEUM DESIGN		DRAWN BY	CHECKED BY
Siddhartha Das Studio		MAHESH PRAKASH	VIVEK NAMDEV
SANITARY, ELECTRICAL, HVAC, FIRE FIGHTING CONSULTANT		DATE	DRAWING TITLE
		22-01-2025	

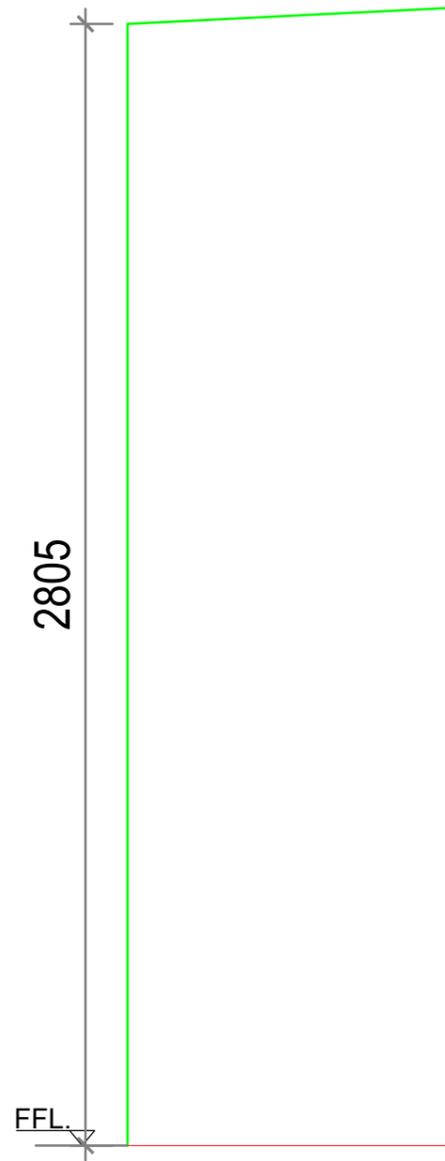


01 Elevation-5  
SCALE - 1:25

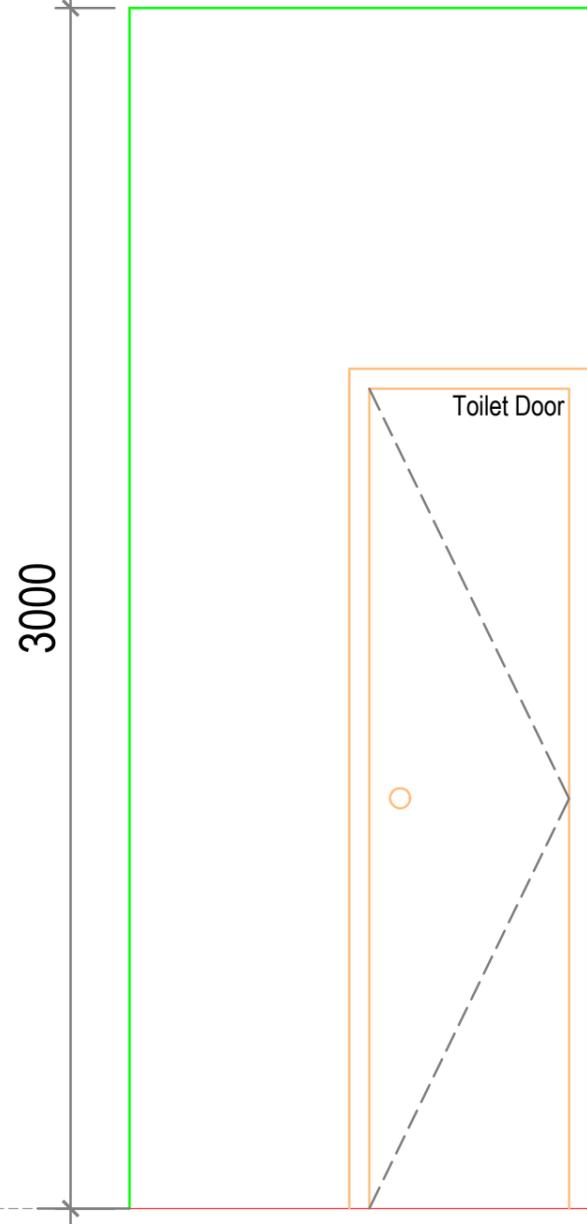


02 Elevation-6  
SCALE - 1:25

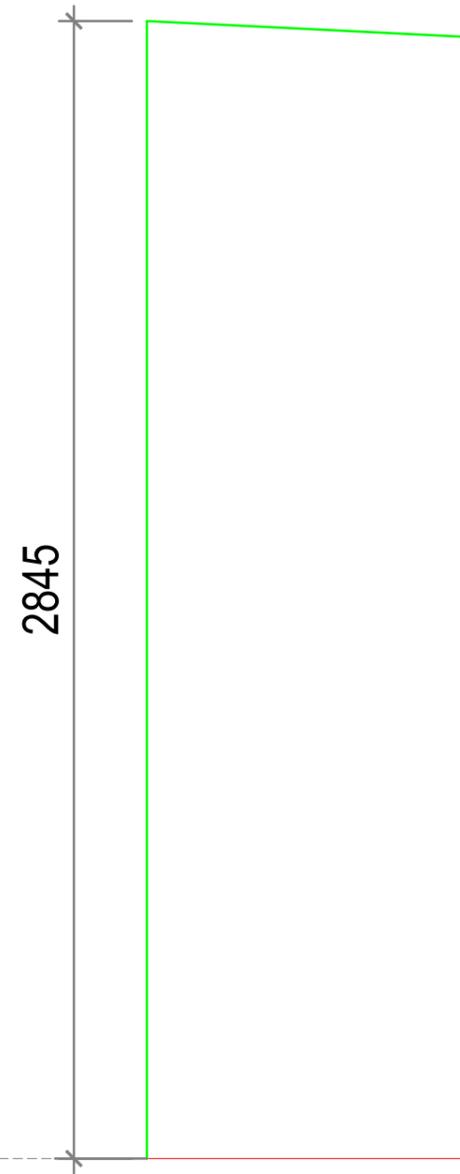

03 Elevation-7  
SCALE - 1:25

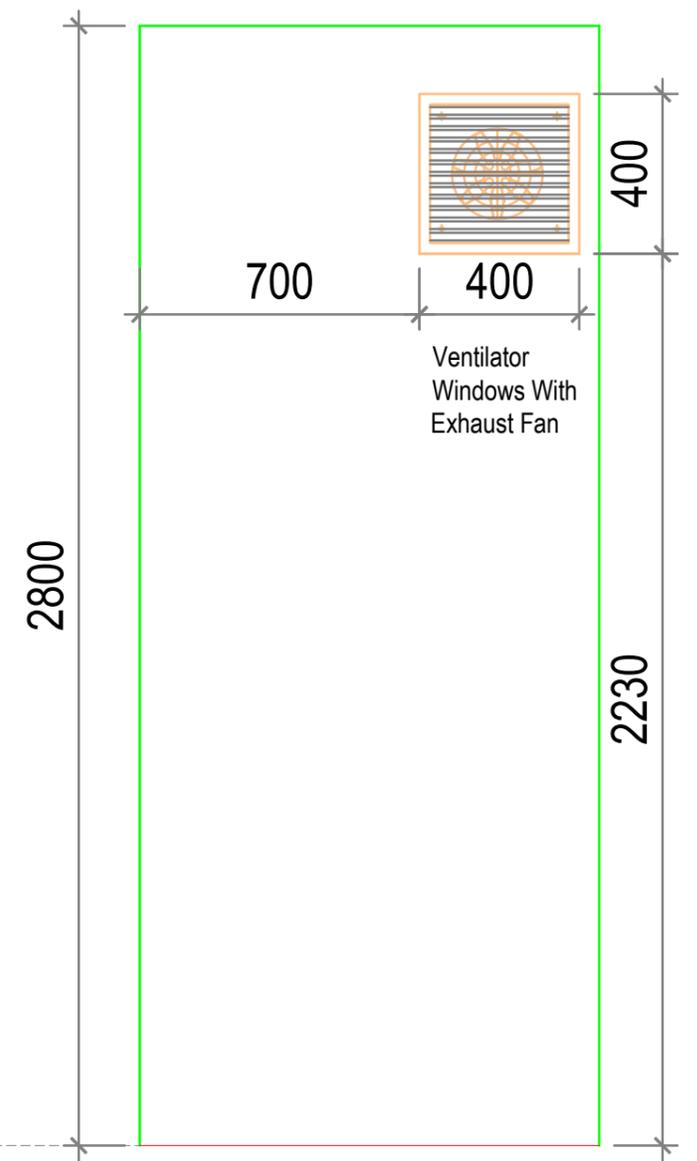

04 Elevation-8  
SCALE - 1:25

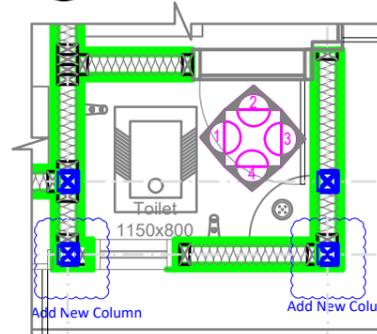


05 Part Plan  
SCALE - 1:50


NOTE:  
THIS DRAWING IS A COPYRIGHT. IT IS THE PROPERTY OF STUDIO VANRO AND IS NOT TO BE REPRODUCED, COPIED, HANDED OVER TO A THIRD PARTY OR USED FOR ANY PURPOSE OTHER THAN THAT FOR WHICH IT HAS BEEN LOANED.

GENERAL NOTES:  
ALL DIMENSIONS INDICATED ARE IN MILLIMETER UNLESS MENTIONED OTHERWISE  
ALL DIMENSIONS ARE TO BE CROSS CHECKED AT SITE AND ANY DISCREPANCY SHALL BE BROUGHT TO NOTICE BEFORE EXECUTION.  
ALL SERVICE DRAWINGS SHALL BE READ IN CONJUNCTION WITH THIS DRAWING AND OTHER DETAILS, ANY DISCREPANCY WHATSOEVER SHALL BE BROUGHT TO NOTICE BEFORE EXECUTION.

S.NO	DATE	DRAWN	CHECKED	VERIFIED	REMARKS
01	22.01.2025	MP	VN	SD/SSG	RO_Drawing Drawn

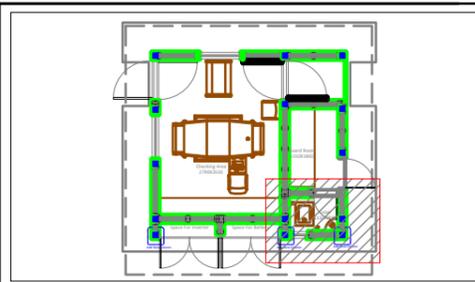


CLIENT		PROJECT	
J D Centre of Art		J D Centre of Art, Bhubaneswar	
ARCHITECT		DRAWING	
Studio VanRO		SECURITY ROOM TOILET- ELEVATIONS	
STRUCTURAL CONSULTANT		SCALE	COMPUTER FILE
Mahendra Raj Consultants Pvt. Ltd		1:25 @ A3	JDCA- Security Room -20250204-MP
MUSEUM DESIGN		DRAWN BY	CHECKED BY
Siddhartha Das Studio		MAHESH PRAKASH	VIVEK NAMDEV
SANITARY, ELECTRICAL, HVAC, FIRE FIGHTING CONSULTANT		DATE	DRAWING TITLE
		22-01-2025	

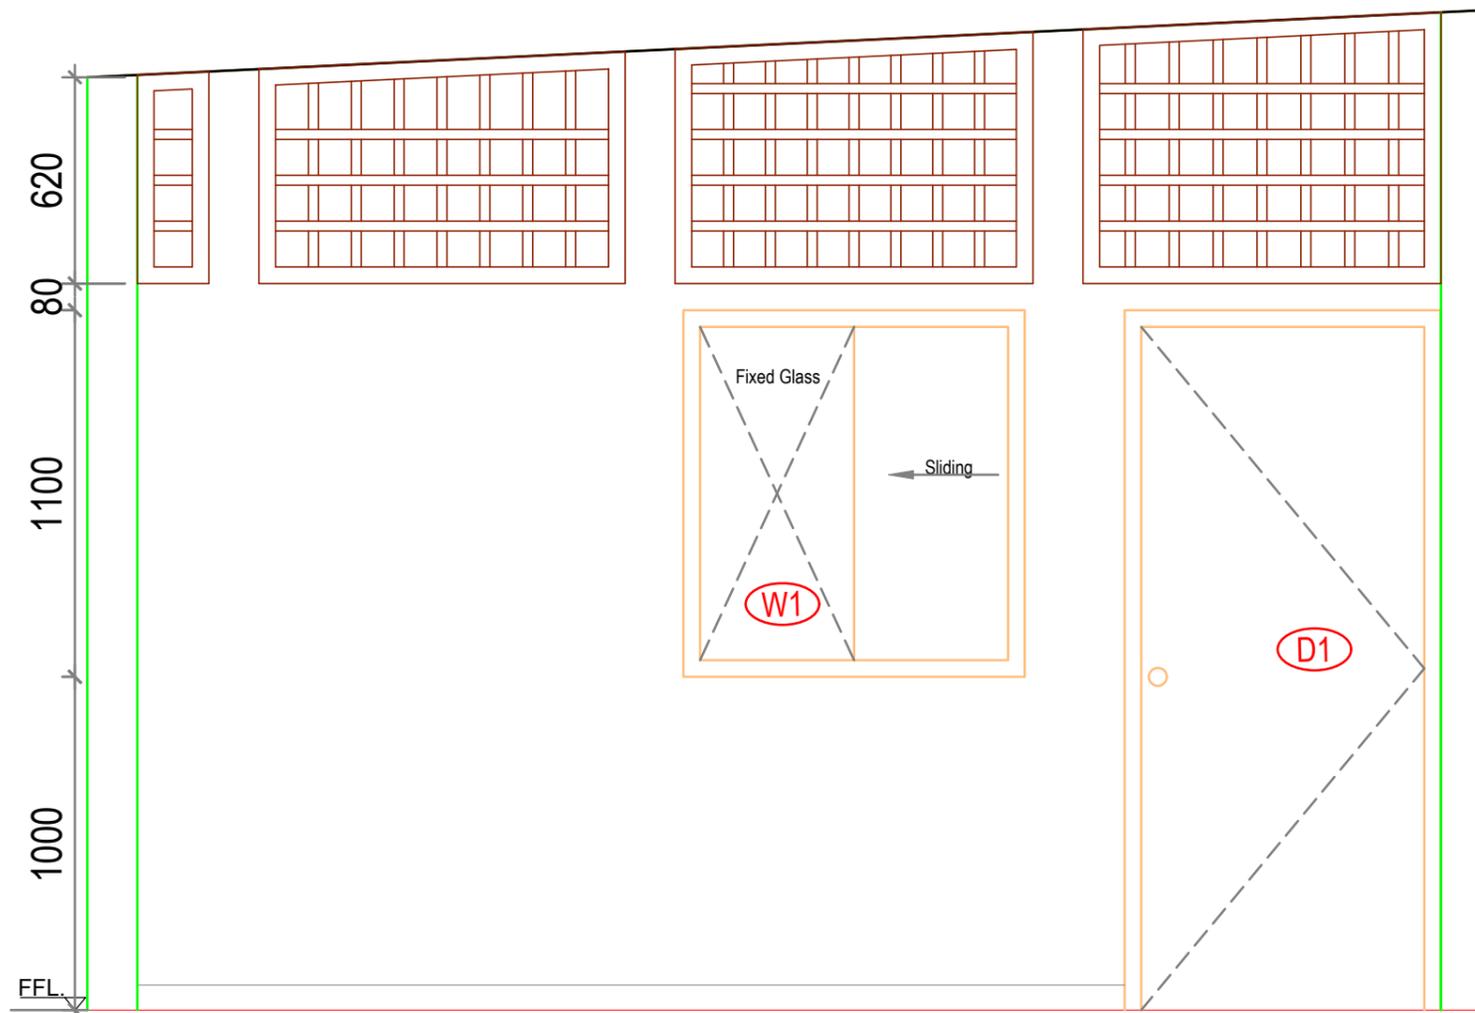

01 Elevation-9  
SCALE - 1:30



02 Elevation-12  
SCALE - 1:30

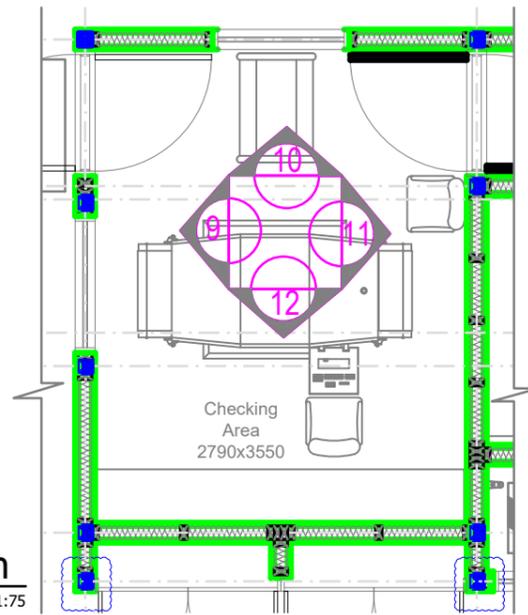

03 Part Plan  
SCALE - 1:75

NOTE:  
THIS DRAWING IS A COPYRIGHT. IT IS THE PROPERTY OF STUDIO VANRO AND IS NOT TO BE REPRODUCED, COPIED, HANDED OVER TO A THIRD PARTY OR USED FOR ANY PURPOSE OTHER THAN THAT FOR WHICH IT HAS BEEN LOANED.

GENERAL NOTES:  
ALL DIMENSIONS INDICATED ARE IN MILLIMETER UNLESS MENTIONED OTHERWISE  
ALL DIMENSIONS ARE TO BE CROSS CHECKED AT SITE AND ANY DISCREPANCY SHALL BE BROUGHT TO NOTICE BEFORE EXECUTION.  
ALL SERVICE DRAWINGS SHALL BE READ IN CONJUNCTION WITH THIS DRAWING AND OTHER DETAILS, ANY DISCREPANCY WHATSOEVER SHALL BE BROUGHT TO NOTICE BEFORE EXECUTION.


S.NO	DATE	DRAWN	CHECKED	VERIFIED	REMARKS
01	22.01.2025	MP	VN	SD/SSG	RO_Drawing Drawn




CLIENT	PROJECT	
J D Centre of Art	J D Centre of Art, Bhubaneswar	
ARCHITECT	DRAWING	
Studio VanRO	SECURITY CHECKING AREA - ELEVATION 9 & 11	
STRUCTURAL CONSULTANT	SCALE	COMPUTER FILE
Mahendra Raj Consultants Pvt. Ltd	1:30 @ A3	JDCA- Security Room -20250204-MP
MUSEUM DESIGN	DRAWN BY	CHECKED BY
Siddhartha Das Studio	MAHESH PRAKASH	VIVEK NAMDEV
SANITARY, ELECTRICAL, HVAC, FIRE FIGHTING CONSULTANT	DATE	DRAWING TITLE
	22-01-2025	






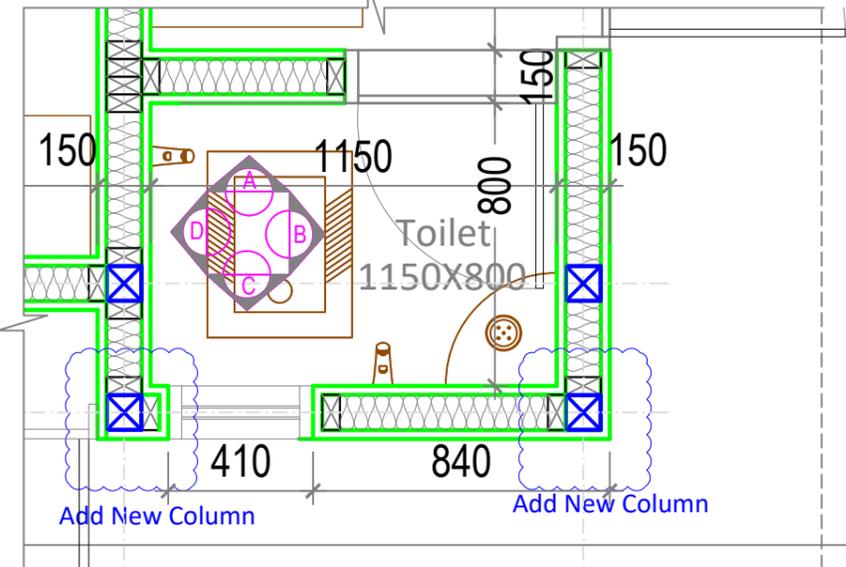


01 Toilet Plan  
SECURITY ROOM TOILET SCALE - 1:20

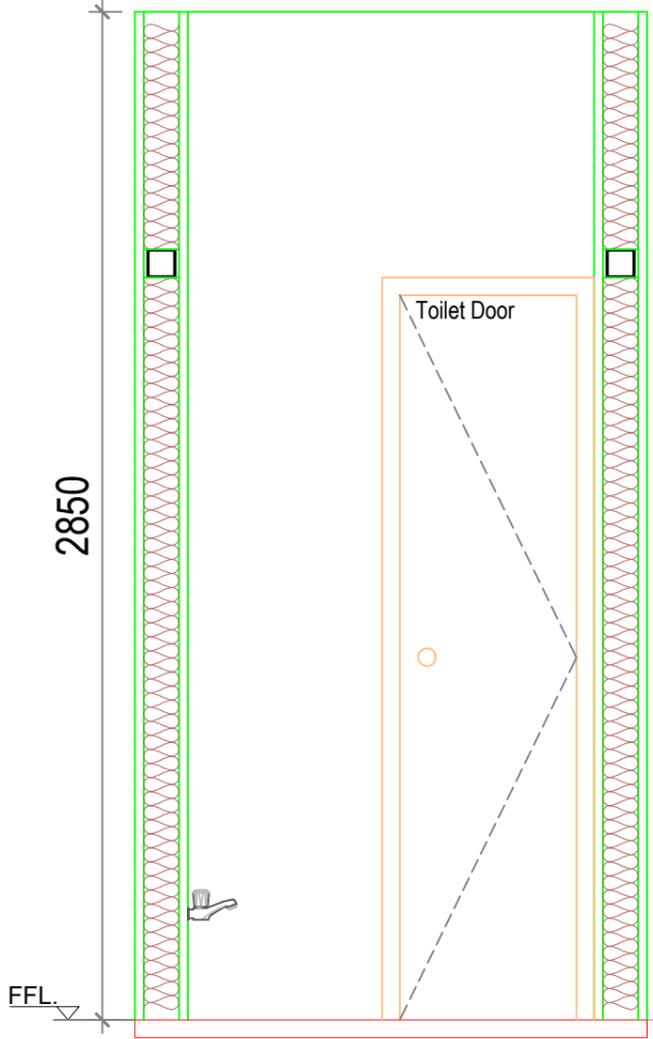


02 Elevation-A  
SCALE - 1:20

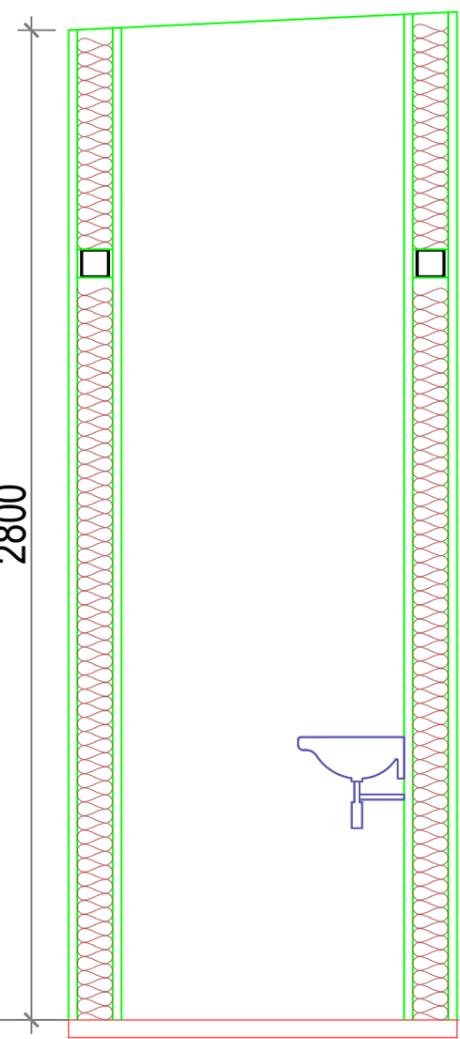

03 Elevation-B  
SCALE - 1:20

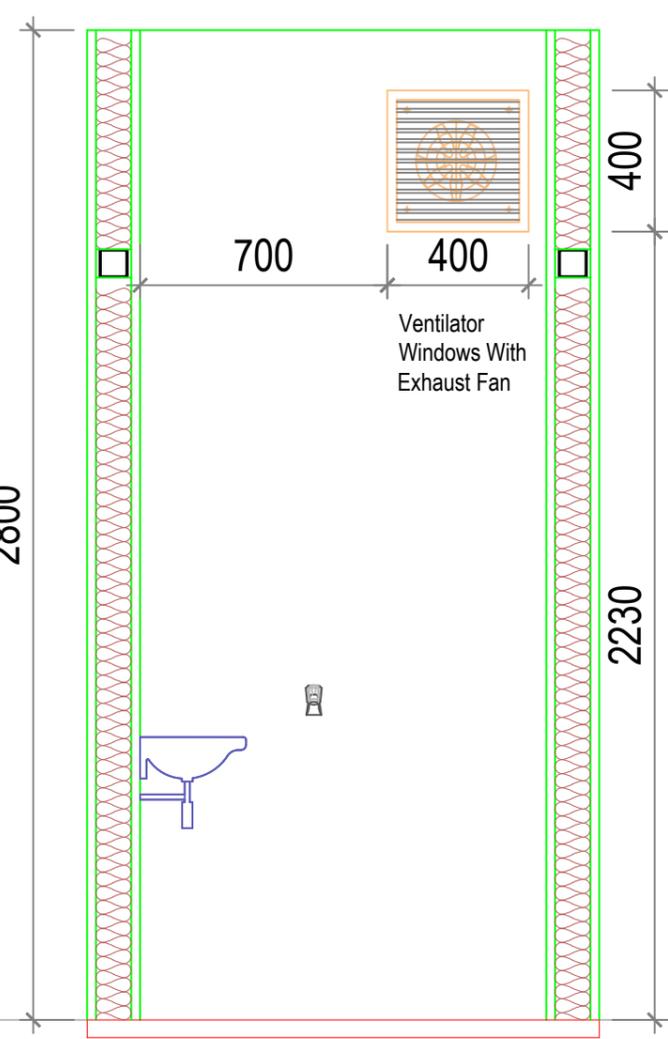

03 Elevation-C  
SCALE - 1:20

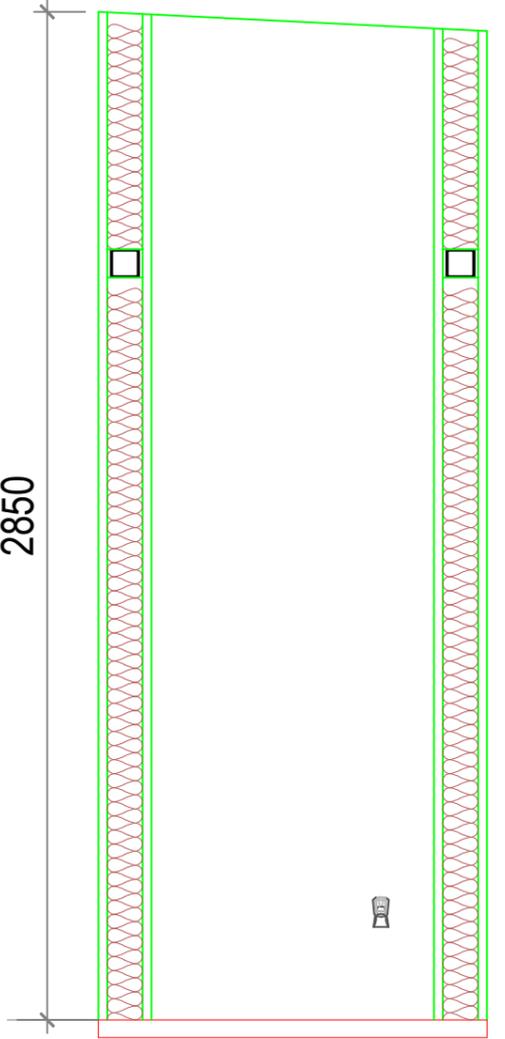


03 Elevation-D  
SCALE - 1:20

NOTE:  
THIS DRAWING IS A COPYRIGHT. IT IS THE PROPERTY OF STUDIO VANRO AND IS NOT TO BE REPRODUCED, COPIED, HANDED OVER TO A THIRD PARTY OR USED FOR ANY PURPOSE OTHER THAN THAT FOR WHICH IT HAS BEEN LOANED.

GENERAL NOTES:  
ALL DIMENSIONS INDICATED ARE IN MILLIMETER UNLESS MENTIONED OTHERWISE  
ALL DIMENSIONS ARE TO BE CROSS CHECKED AT SITE AND ANY DISCREPANCY SHALL BE BROUGHT TO NOTICE BEFORE EXECUTION.  
ALL SERVICE DRAWINGS SHALL BE READ IN CONJUNCTION WITH THIS DRAWING AND OTHER DETAILS, ANY DISCREPANCY WHATSOEVER SHALL BE BROUGHT TO NOTICE BEFORE EXECUTION.

S.NO	DATE	DRAWN	CHECKED	VERIFIED	REMARKS
01	21.04.2025	MP	VN	SD/SSG	RO_Drawing Drawn

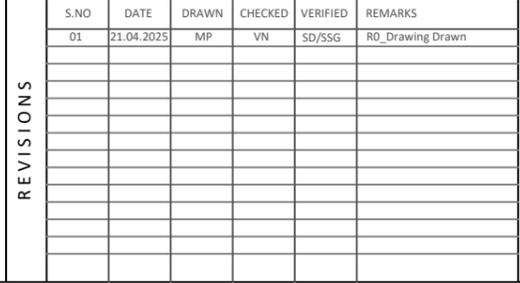

CLIENT	PROJECT	
J D Centre of Art	J D Centre of Art, Bhubaneswar	
ARCHITECT	DRAWING	
Studio VanRO	SECURITY ROOM TOILET PLAN & ELEVATIONS	
STRUCTURAL CONSULTANT	SCALE	COMPUTER FILE
Mahendra Raj Consultants Pvt. Ltd	1:25 @ A3	JDCA- Security Room -20250204-MP
MUSEUM DESIGN	DRAWN BY	CHECKED BY
Siddhartha Das Studio	MAHESH PRAKASH	VIVEK NAMDEV
SANITARY, ELECTRICAL, HVAC, FIRE FIGHTING CONSULTANT	DATE	DRAWING TITLE
	21-04-2025	

CLIENT	PROJECT	
J D Centre of Art	J D Centre of Art, Bhubaneswar	
ARCHITECT	DRAWING	
Studio VanRO	SECURITY ROOM TOILET PLAN & ELEVATIONS	
STRUCTURAL CONSULTANT	SCALE	COMPUTER FILE
Mahendra Raj Consultants Pvt. Ltd	1:25 @ A3	JDCA- Security Room -20250204-MP
MUSEUM DESIGN	DRAWN BY	CHECKED BY
Siddhartha Das Studio	MAHESH PRAKASH	VIVEK NAMDEV
SANITARY, ELECTRICAL, HVAC, FIRE FIGHTING CONSULTANT	DATE	DRAWING TITLE
	21-04-2025	