




01 Ground Floor Staircase Plan
Scale 1:100

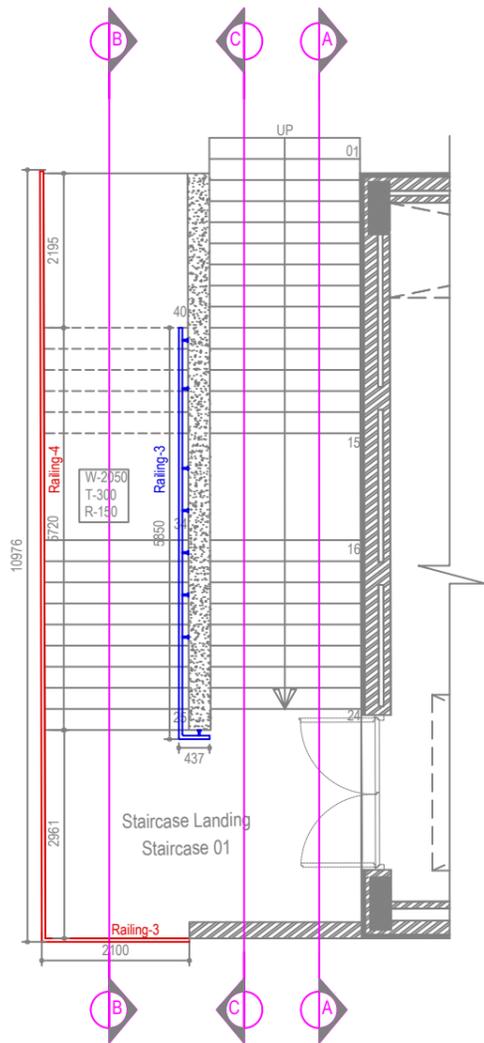

02 First Floor Staircase Plan
Scale 1:100

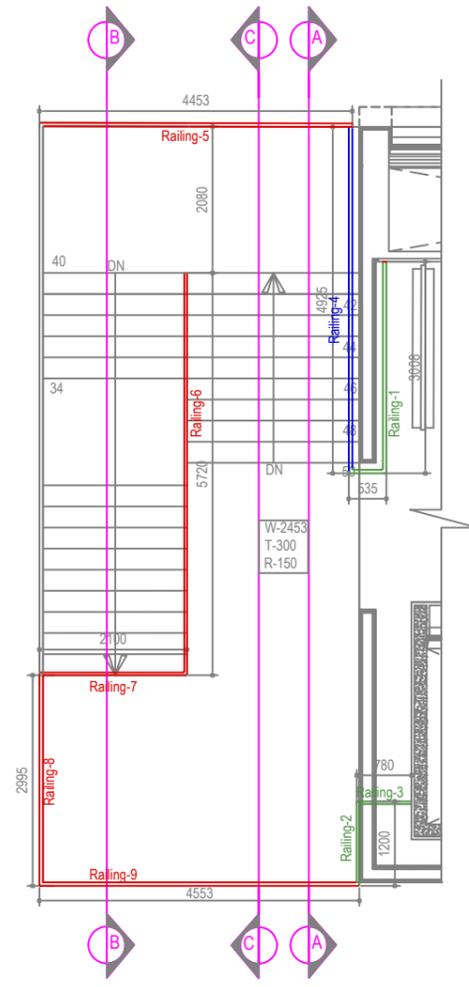

03 Second Floor Staircase Plan
Scale 1:100

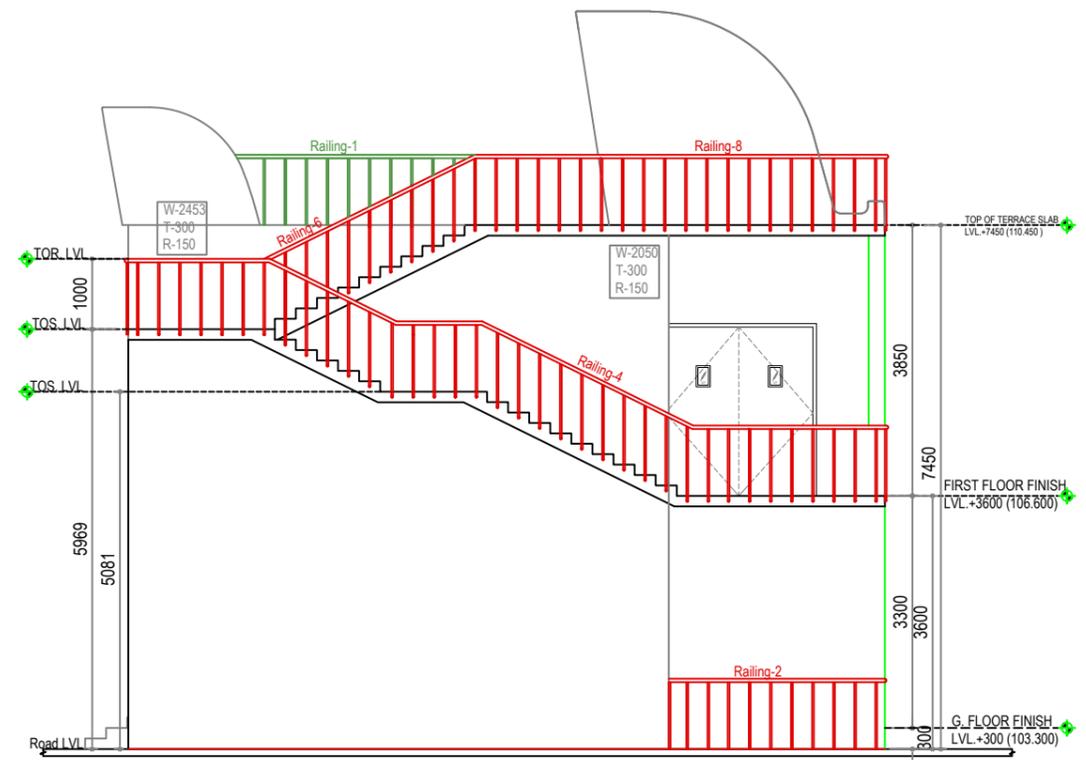

04 Front Staircase
Scale 1:100


S.No	Railing	Length(m)
1	Railing-1	7.88
2	Railing-2	8.29
3	Railing-3	6.34
4	Railing-4	5.29
5	Railing-1	2.04
6	Railing-2	3.07
7	Railing-3	2.1
8	Railing-4	11.31
9	Railing-5	4.45
10	Railing-6	5.72
11	Railing-7	2.1
12	Railing-8	2.99
13	Railing-9	4.55
14	Railing-1	3.53
15	Railing-2	0.78
16	Railing-3	3.07
	Total	27.8
	Total	38.33
	Total	7.38

NOTE:
THIS DRAWING IS A COPYRIGHT. IT IS THE PROPERTY OF STUDIO VANRO AND IS NOT TO BE REPRODUCED, COPIED, HANDED OVER TO A THIRD PARTY OR USED FOR ANY PURPOSE OTHER THAN THAT FOR WHICH IT HAS BEEN LOANED.


GENERAL NOTES:
ALL DIMENSIONS INDICATED ARE IN MILLIMETER UNLESS MENTIONED OTHERWISE
ALL DIMENSIONS ARE TO BE CROSS CHECKED AT SITE AND ANY DISCREPANCY SHALL BE BROUGHT TO NOTICE BEFORE EXECUTION.
ALL SERVICE DRAWINGS SHALL BE READ IN CONJUNCTION WITH THIS DRAWING AND OTHER DETAILS.
ANY DISCREPANCIES IN DRAWING MUST BE REPORTED IMMEDIATELY TO PM/ARCHITECT FOR FINAL DECISION BEFORE EXECUTION.

Note:-
1. All Railing Marked in Red Color are Side Mounted Balustrade with Handrail
2. Blue are Handrail
3. Green Color Floor Mounted Balustrade with Handrail


S.NO	DATE	DRAWN	CHECKED	VERIFIED	REMARKS
1	4-1-2024	MP	VD	SD/SSG	RO

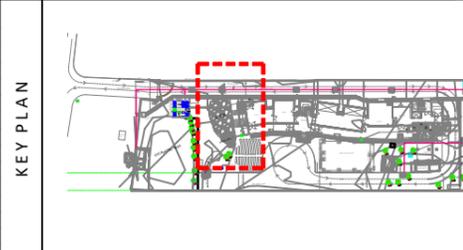

CLIENT	J D Centre of Art	
PROJECT	J D Centre of Art, Bhubaneswar	
ARCHITECT	STUDIO VanRO	
DRAWING	FIRE STAIRCASE RAILING	
STRUCTURAL CONSULTANT	SCALE	COMPUTER FILE
Mahendra Raj Consultants Pvt. Ltd	1:100	JCA- FIRE STAIRCASE RAILING-20240104-MP
MUSEUM DESIGN	DRAWN BY	CHECKED BY
Siddhartha Das Studio	MAHESH PRAKASH	VIVEK NAMDEV
SANITARY, ELECTRICAL, HVAC, FIRE FIGHTING CONSULTANT	DATE	DRAWING TITLE
	28-02-2025	

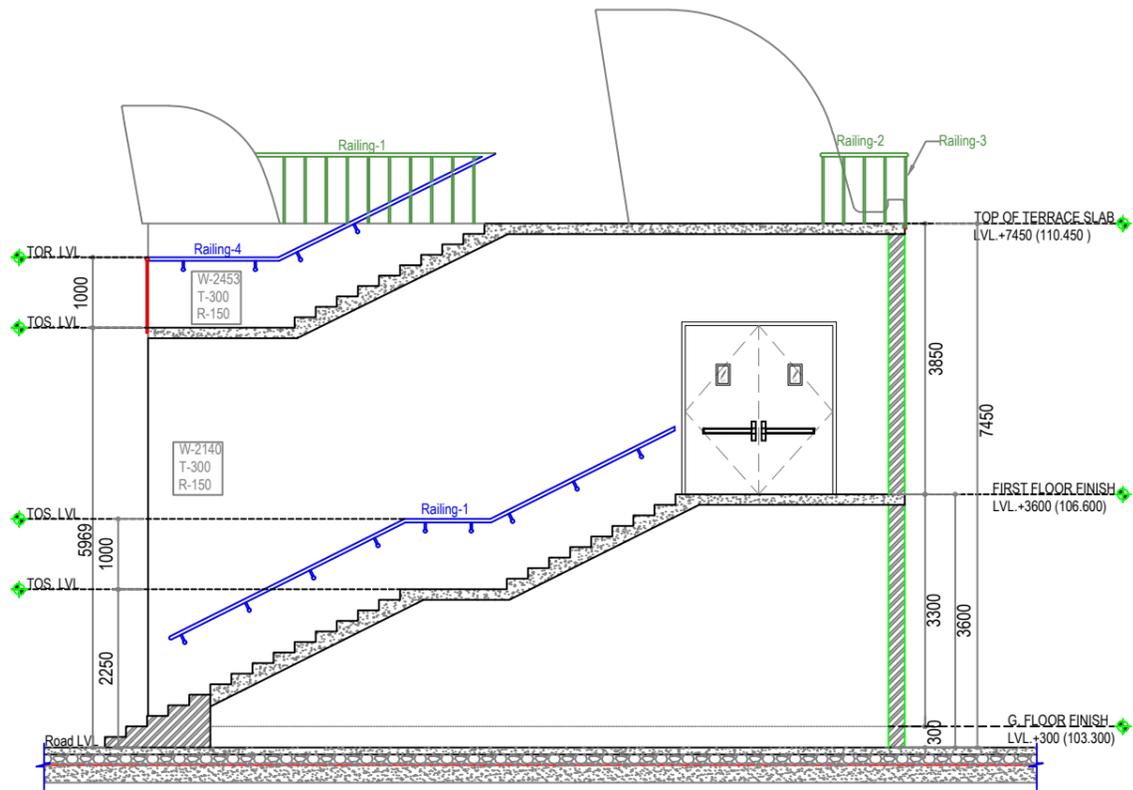


05 Section-A
Scale 1:100

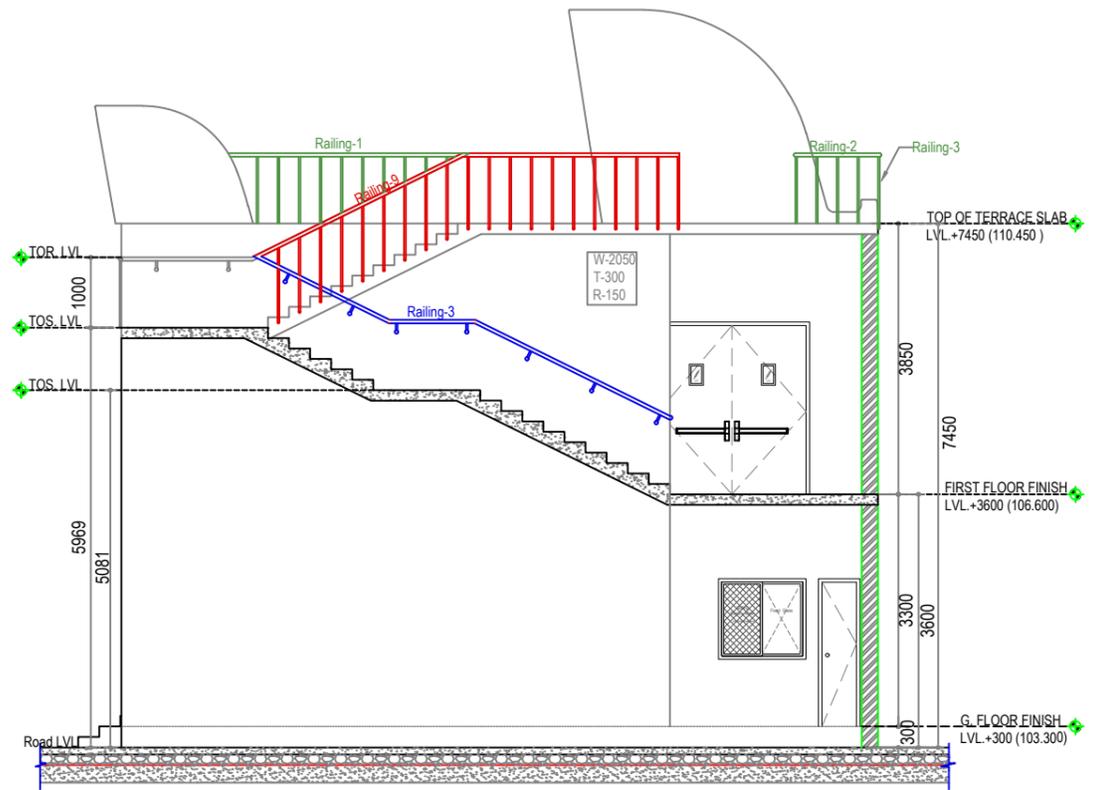

06 Section-B
Scale 1:100

S.No	Railing	Length(m)
1	Railing-1	7.88
2	Railing-2	8.29
3	Railing-3	6.34
4	Railing-4	5.29
5	Railing-1	2.04
6	Railing-2	3.07
7	Railing-3	2.1
8	Railing-4	11.31
9	Railing-5	4.45
10	Railing-6	5.72
11	Railing-7	2.1
12	Railing-8	2.99
13	Railing-9	4.55
14	Railing-1	3.53
15	Railing-2	0.78
16	Railing-3	3.07
	Total	27.8
	Total	38.33
	Total	7.38

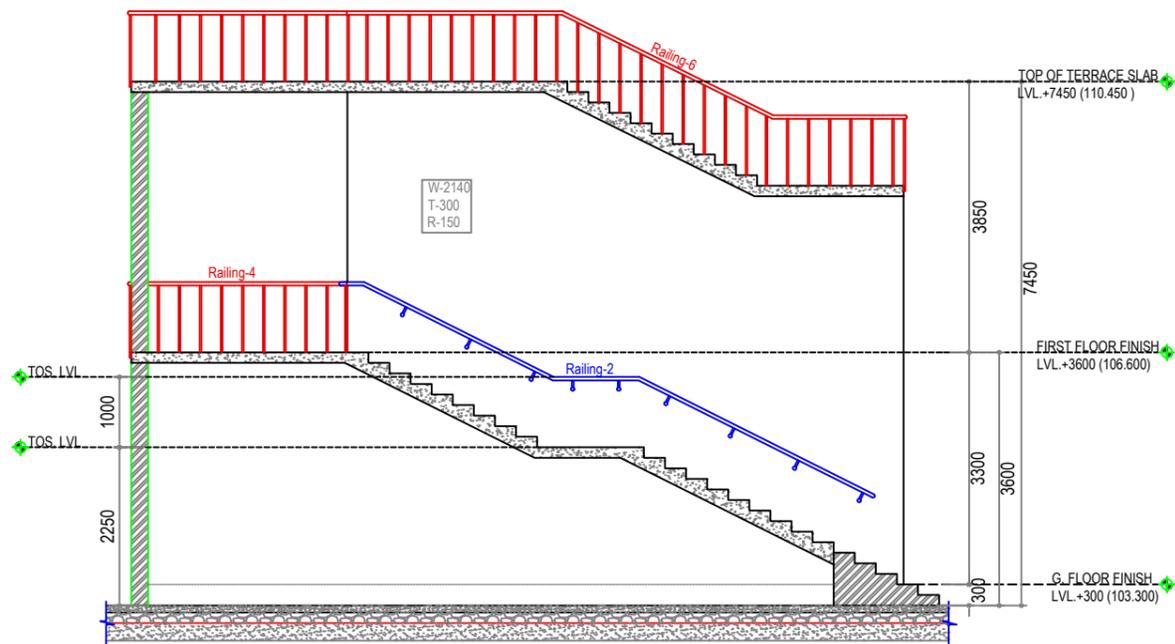


07 Section-C
Scale 1:100

NOTE:
THIS DRAWING IS A COPYRIGHT. IT IS THE PROPERTY OF STUDIO VANRO AND IS NOT TO BE REPRODUCED, COPIED, HANDED OVER TO A THIRD PARTY OR USED FOR ANY PURPOSE OTHER THAN THAT FOR WHICH IT HAS BEEN LOANED.


GENERAL NOTES:
ALL DIMENSIONS INDICATED ARE IN MILLIMETER UNLESS MENTIONED OTHERWISE
ALL DIMENSIONS ARE TO BE CROSS CHECKED AT SITE AND ANY DISCREPANCY SHALL BE BROUGHT TO NOTICE BEFORE EXECUTION.
ALL SERVICE DRAWINGS SHALL BE READ IN CONJUNCTION WITH THIS DRAWING AND OTHER DETAILS.
ANY DISCREPANCIES IN DRAWING MUST BE REPORTED IMMEDIATELY TO PM/ARCHITECT FOR FINAL DECISION BEFORE EXECUTION.

Note:-
1. All Railing Marked in Red Color are Side Mounted Balustrade with Handrail
2. Blue are Handrail
3. Green Color Floor Mounted Balustrade with Handrail


S.NO	DATE	DRAWN	CHECKED	VERIFIED	REMARKS
1	4-1-2024	MP	VD	SD/SSG	RD

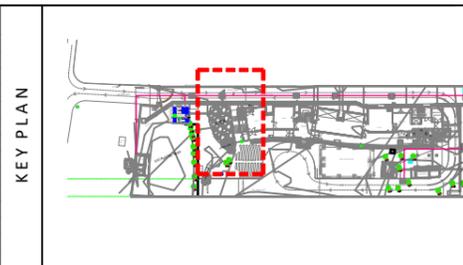


CLIENT		PROJECT	
J D Centre of Art		J D Centre of Art, Bhubaneswar	
ARCHITECT		DRAWING	
STUDIO VanRO		FIRE STAIRCASE RAILING	
STRUCTURAL CONSULTANT		SCALE	
Mahendra Raj Consultants Pvt. Ltd		1:100	
MUSEUM DESIGN		COMPUTER FILE	
Siddhartha Das Studio		JCA- FIRE STAIRCASE RAILING-20240104.MP	
SANITARY, ELECTRICAL, HVAC, FIRE FIGHTING CONSULTANT		DRAWN BY	
		MAHESH PRAKASH	
DATE		CHECKED BY	
28-02-2025		VIVEK NAMDEV	
DRAWING TITLE			

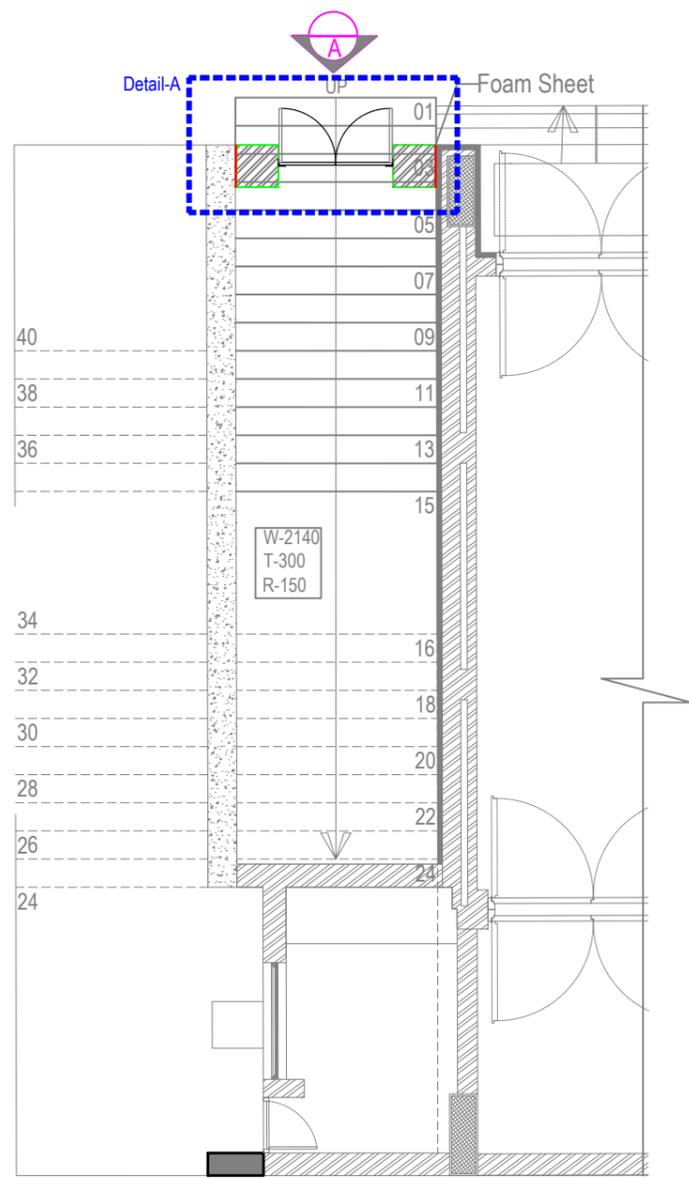

01 Ground Floor Staircase Plan
Scale 1:75

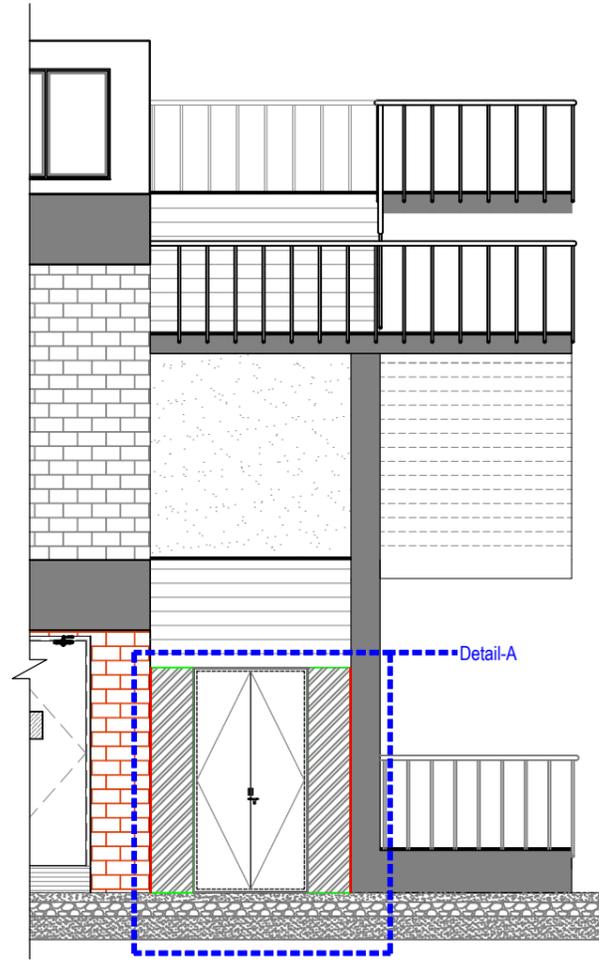

02 Elevation-A
Scale 1:75

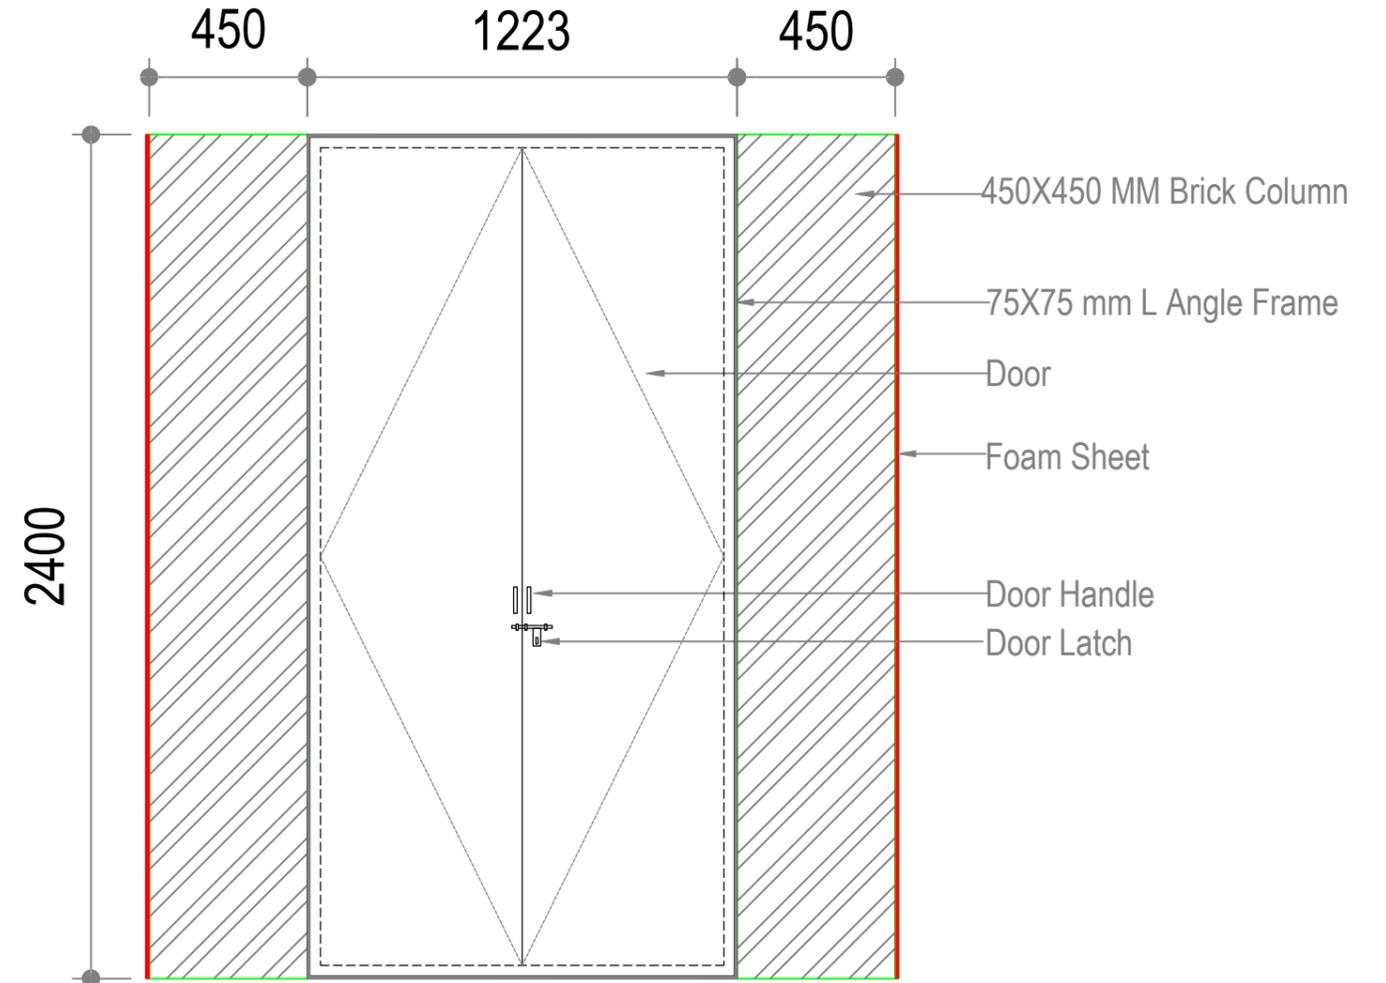


03 Detail-A
Scale 1:20


NOTE:
THIS DRAWING IS A COPYRIGHT. IT IS THE PROPERTY OF STUDIO VANRO AND IS NOT TO BE REPRODUCED, COPIED, HANDED OVER TO A THIRD PARTY OR USED FOR ANY PURPOSE OTHER THAN THAT FOR WHICH IT HAS BEEN LOANED.

GENERAL NOTES:
ALL DIMENSIONS INDICATED ARE IN MILLIMETER UNLESS MENTIONED OTHERWISE
ALL DIMENSIONS ARE TO BE CROSS CHECKED AT SITE AND ANY DISCREPANCY SHALL BE BROUGHT TO NOTICE BEFORE EXECUTION.
ALL SERVICE DRAWINGS SHALL BE READ IN CONJUNCTION WITH THIS DRAWING AND OTHER DETAILS.
ANY DISCREPANCIES IN DRAWING MUST BE REPORTED IMMEDIATELY TO PMCI/ARCHITECT FOR FINAL DECISION BEFORE EXECUTION.


S.NO	DATE	DRAWN	CHECKED	VERIFIED	REMARKS

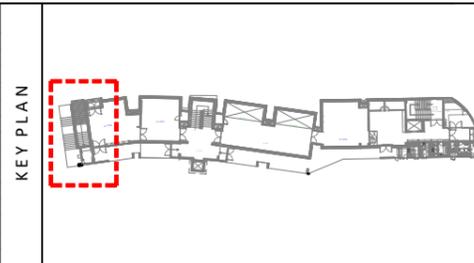


CLIENT		PROJECT	
J D Centre of Art		J D Centre of Art, Bhubaneswar	
ARCHITECT		DRAWING	
STUDIO VanRO		FIRE STAIRCASE DOOR DETAIL	
STRUCTURAL CONSULTANT		SCALE	COMPUTER FILE
Mahendra Raj Consultants Pvt. Ltd		1:75	JCA- FIRE STAIRCASE RAILING-20240104.MP
MUSEUM DESIGN		DRAWN BY	CHECKED BY
Siddhartha Das Studio		MAHESH PRAKASH	VIVEK NAMDEV
SANITARY, ELECTRICAL, HVAC, FIRE FIGHTING CONSULTANT		DATE	DRAWING TITLE
		19-08-2025	

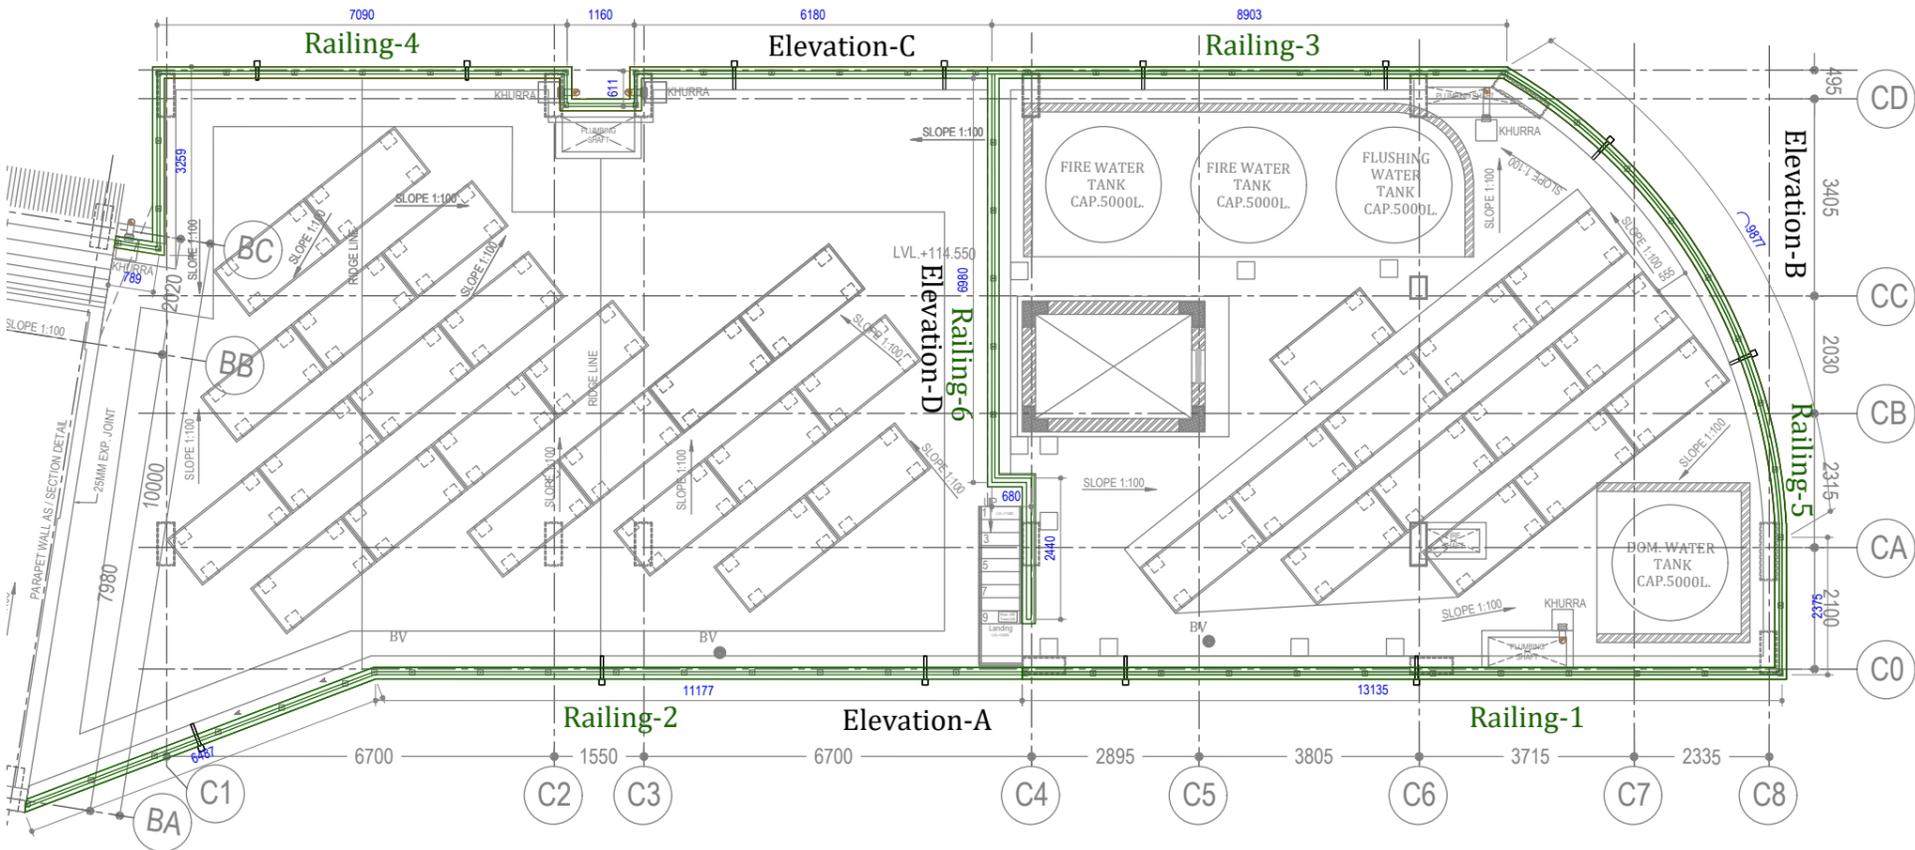


01 Roof Plan Block-2
Nts

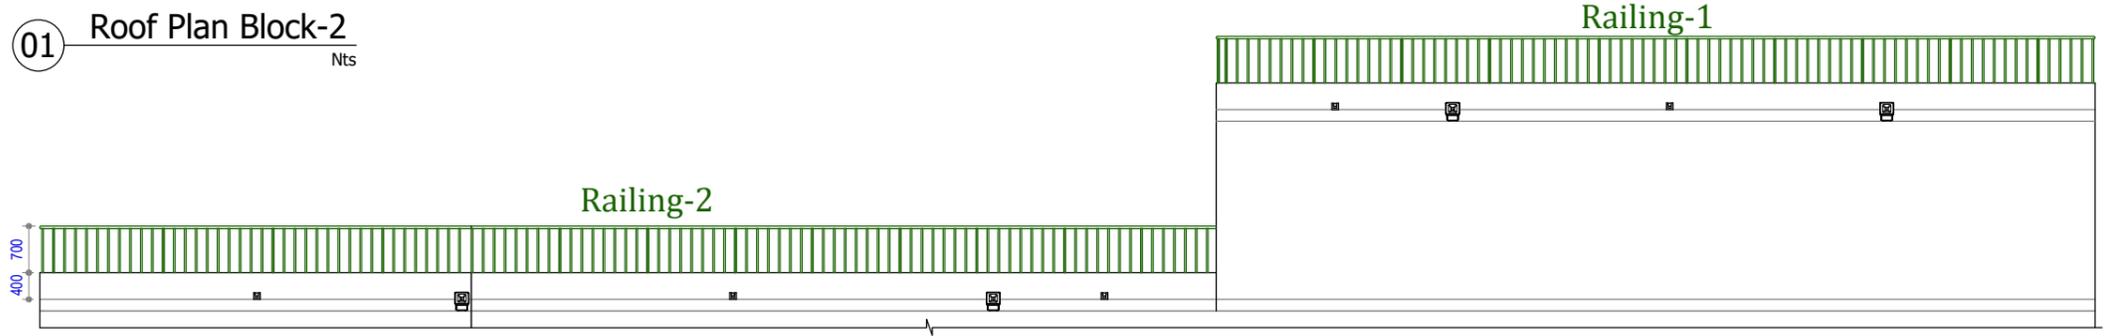


02 Elevation-A
1:75

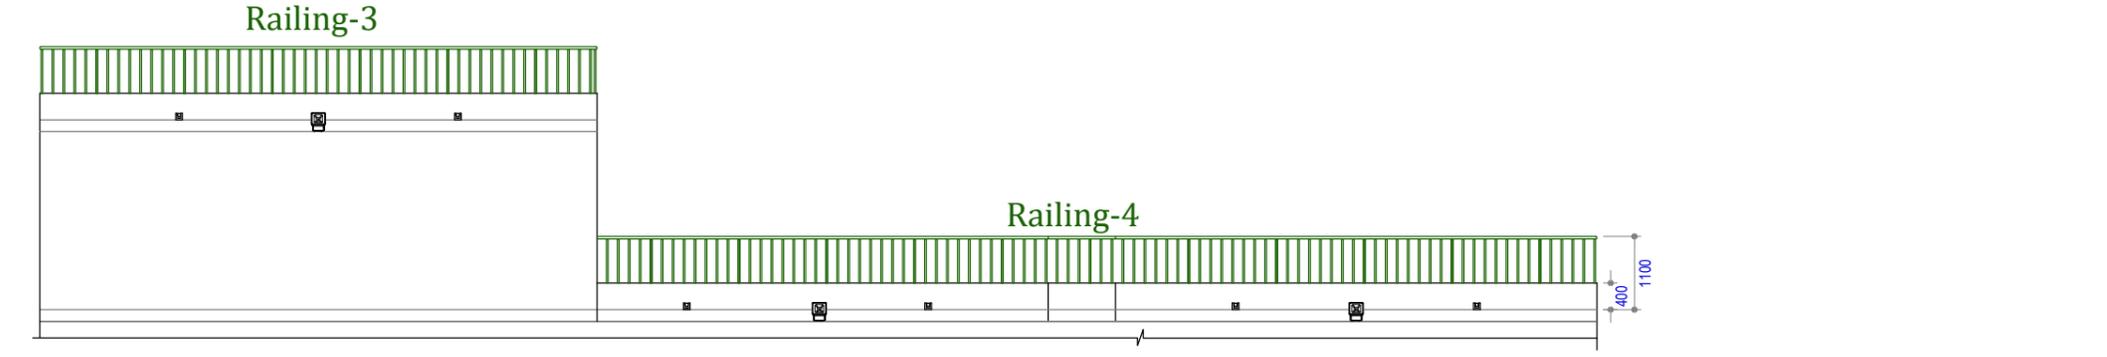

03 Elevation-C
1:75

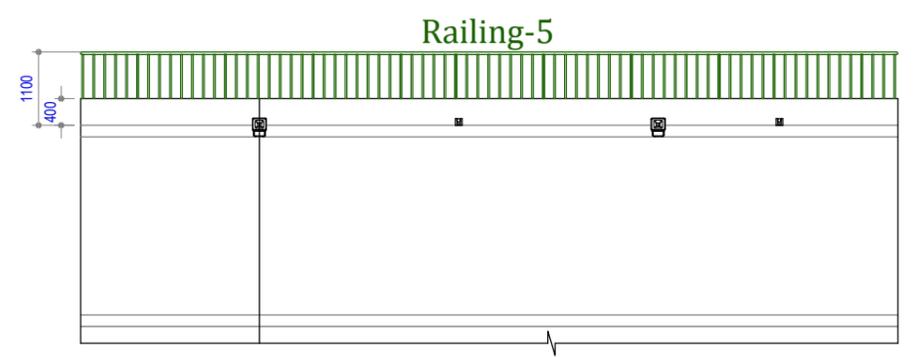

04 Elevation-B
1:75

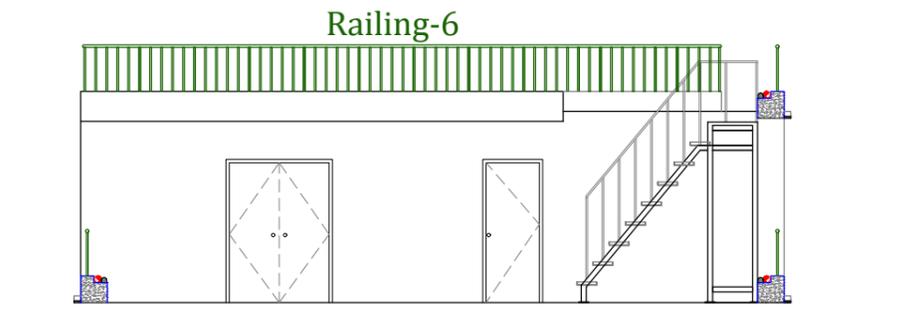

05 Elevation-D
1:75

S.No	Railing	Length(m)
1	Railing-1	13.13
2	Railing-2	17.66
3	Railing-3	8.90
4	Railing-4	19.70
5	Railing-5	12.25
6	Railing-6	10.10
7	Railing-7	2.69
8	Railing-8	10.06
9	Railing-9	2.25
10	Railing-10	2.05
	Total	98.79


NOTE:
THIS DRAWING IS A COPYRIGHT. IT IS THE PROPERTY OF STUDIO VANRO AND IS NOT TO BE REPRODUCED, COPIED, HANDED OVER TO A THIRD PARTY OR USED FOR ANY PURPOSE OTHER THAN THAT FOR WHICH IT HAS BEEN LOANED.


GENERAL NOTES:
ALL DIMENSIONS INDICATED ARE IN MILLIMETER UNLESS MENTIONED OTHERWISE
ALL DIMENSIONS ARE TO BE CROSS CHECKED AT SITE AND ANY DISCREPANCY SHALL BE BROUGHT TO NOTICE BEFORE EXECUTION.
ALL SERVICE DRAWINGS SHALL BE READ IN CONJUNCTION WITH THIS DRAWING AND OTHER DETAILS.
ANY DISCREPANCIES IN DRAWING MUST BE REPORTED IMMEDIATELY TO PM/ARCHITECT FOR FINAL DECISION BEFORE EXECUTION.

Note:-
1. All Railing Marked in Red Color are Side Mounted Balustrade with Handrail
2. Blue are Handrail
3. Green Color Floor Mounted Balustrade with Handrail


S.NO	DATE	DRAWN	CHECKED	VERIFIED	REMARKS

CLIENT	PROJECT
J D Centre of Art	J D Centre of Art, Bhubaneswar
ARCHITECT	DRAWING
VASTU SHILPA Consultants/ STUDIO VanRO	RAILING PLAN & ELEVATIONS
STRUCTURAL CONSULTANT	SCALE
Mahendra Raj Consultants Pvt. Ltd	1:75@A2
MUSEUM DESIGN	COMPUTER FILE
Siddhartha Das Studio	JDCA- Roof Railing Detail 20250305-MP
SANITARY, ELECTRICAL, HVAC, FIRE FIGHTING CONSULTANT	DRAWN BY
	MAHESH PRAKASH
	VIVEK NAMDEV
	DATE
	05-03-2025
	DRAWING TITLE

 

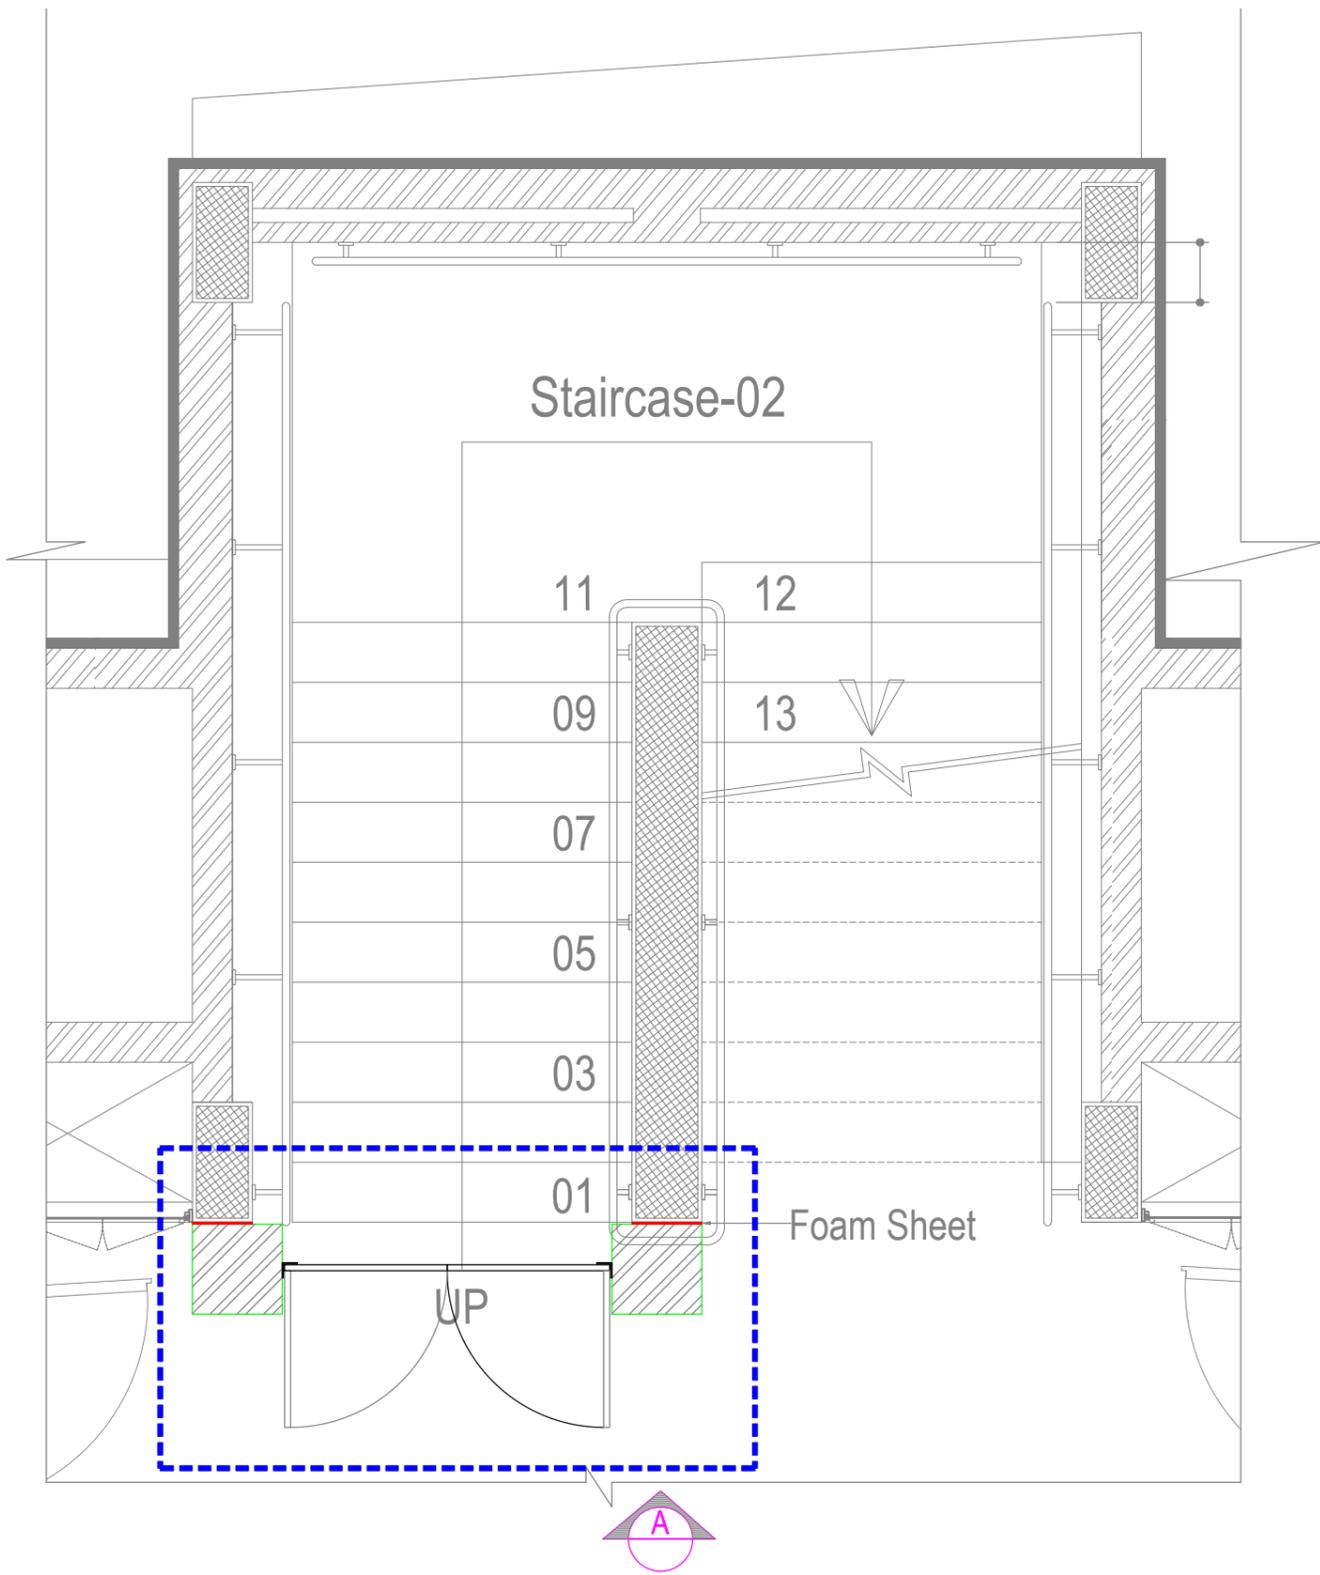

01 Ground Floor Block-1 Staircase Plan
SCALE 1:25

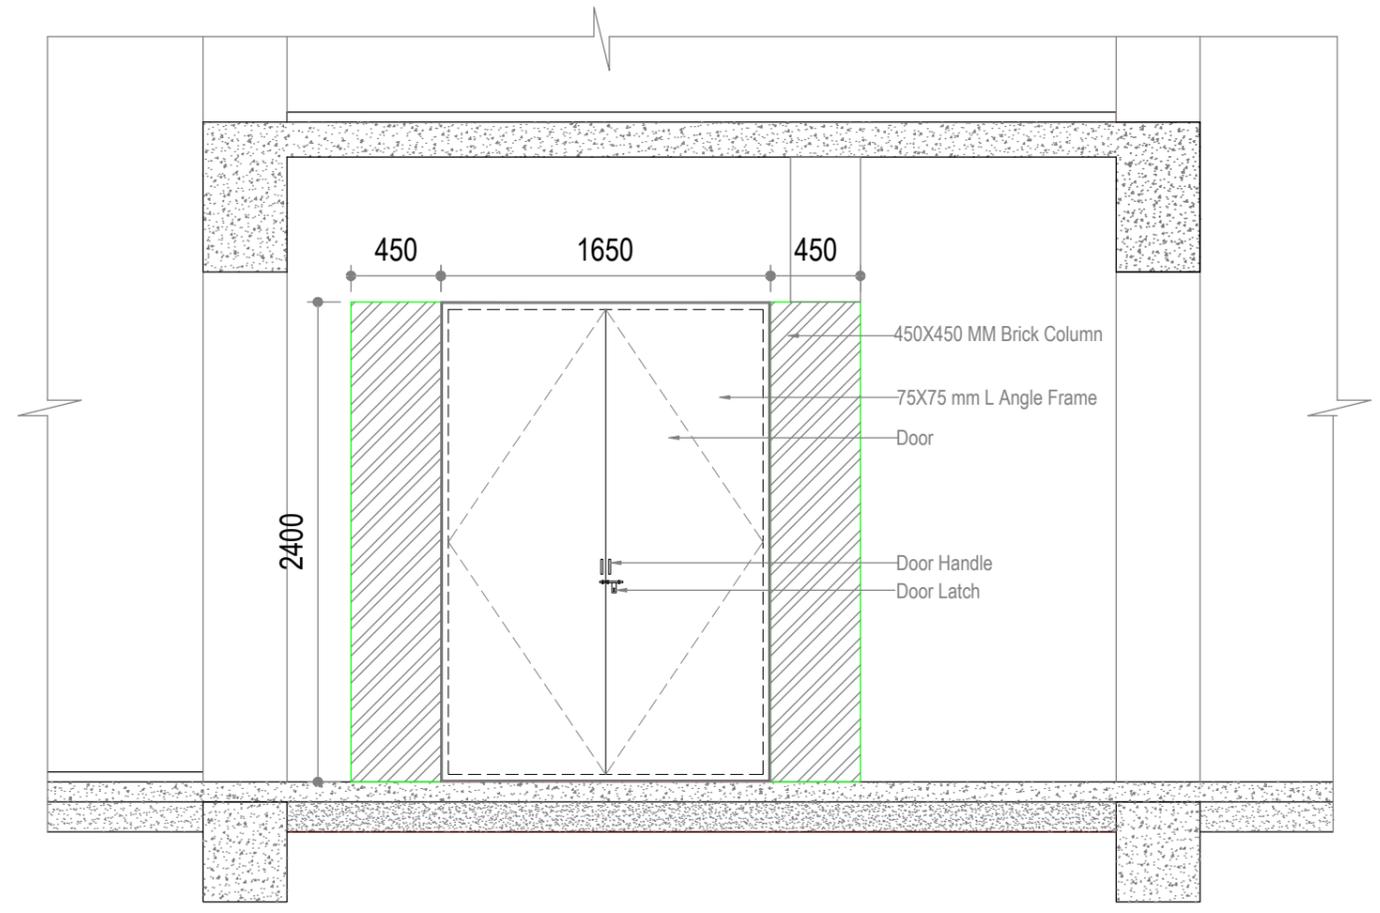


02 Elevation-A
SCALE 1:25


NOTE:
THIS DRAWING IS A COPYRIGHT. IT IS THE PROPERTY OF STUDIO VANRO AND IS NOT TO BE REPRODUCED, COPIED, HANDED OVER TO A THIRD PARTY OR USED FOR ANY PURPOSE OTHER THAN THAT FOR WHICH IT HAS BEEN LOANED.

GENERAL NOTES:
ALL DIMENSIONS INDICATED ARE IN MILLIMETER UNLESS MENTIONED OTHERWISE
ALL DIMENSIONS ARE TO BE CROSS CHECKED AT SITE AND ANY DISCREPANCY SHALL BE BROUGHT TO NOTICE BEFORE EXECUTION.
ALL SERVICE DRAWINGS SHALL BE READ IN CONJUNCTION WITH THIS DRAWING AND OTHER DETAILS.
ANY DISCREPANCIES IN DRAWING MUST BE REPORTED IMMEDIATELY TO PMC FOR FINAL DECISION.


S.NO	DATE	DRAWN	CHECKED	VERIFIED	REMARKS

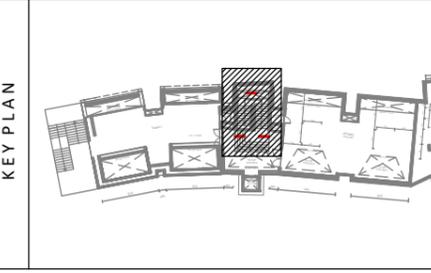


CLIENT	J D Centre of Art		PROJECT	J D Centre of Art, Bhubaneshwar	
ARCHITECT	Vastu Shilpa Consultants/ Studio VanRO		DRAWING	STAIRCASE DOOR DETAIL (BLOCK-1)	
STRUCTURAL CONSULTANT	Mahendra Raj Consultants Pvt. Ltd		SCALE	1:25 @ A2	COMPUTER FILE
MUSEUM DESIGN	Siddhartha Das Studio		DRAWN BY	MAHESH PRAKASH	CHECKED BY
SANITARY, ELECTRICAL, HVAC, FIRE FIGHTING CONSULTANT			DATE	19-08-2025	DRAWING TITLE

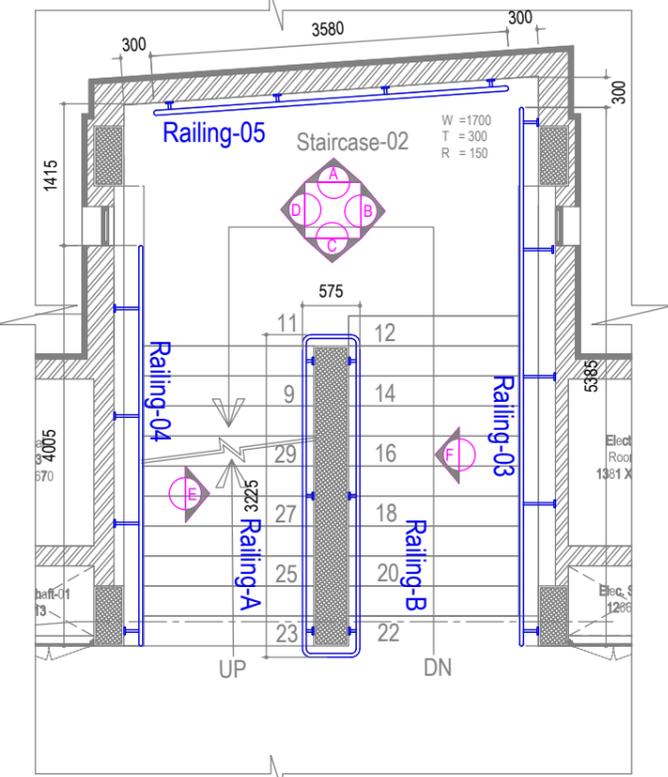

02 First floor Block-1 Staircase Plan
Scale 1:50

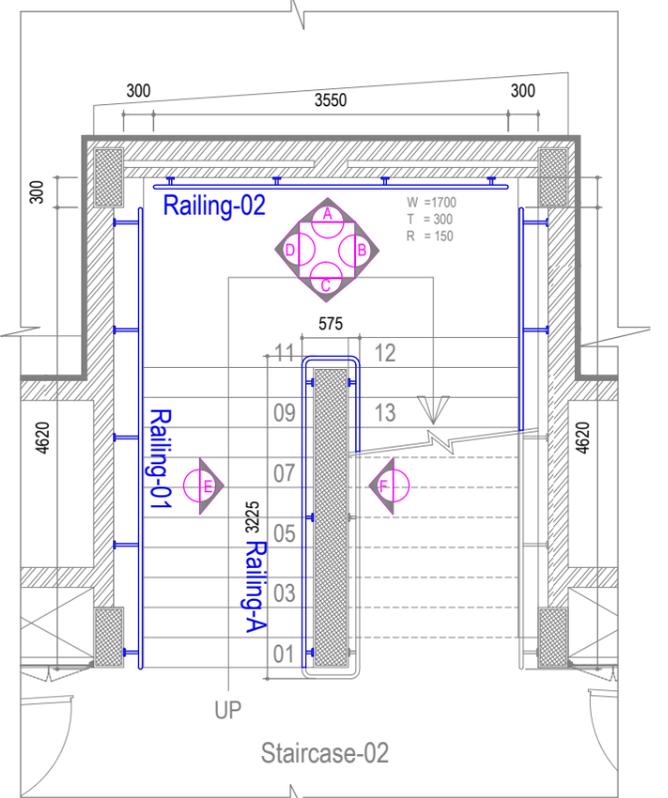


01 Ground floor Block-1 Staircase Plan
Scale 1:50

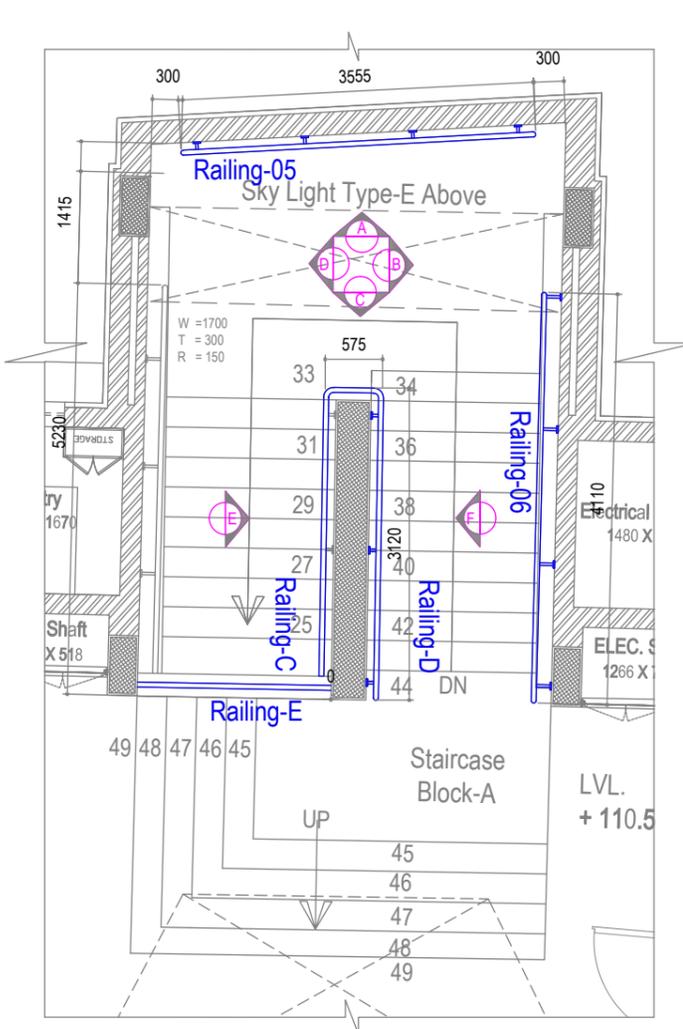

03 Second floor Block-1 Staircase Plan
Scale 1:50

S.No	Railing	Length(m)
1	Railing-1	5.57
2	Railing-2	3.51
3	Railing-3	5.44
4	Railing-4	4.38
5	Railing-5	3.49
6	Railing-6	4.34
7	Railing-A	3.96
8	Railing-B	4.11
9	Railing-C	4.12
10	Railing-D	3.53
11	Railing-E	1.93
Total		44.38

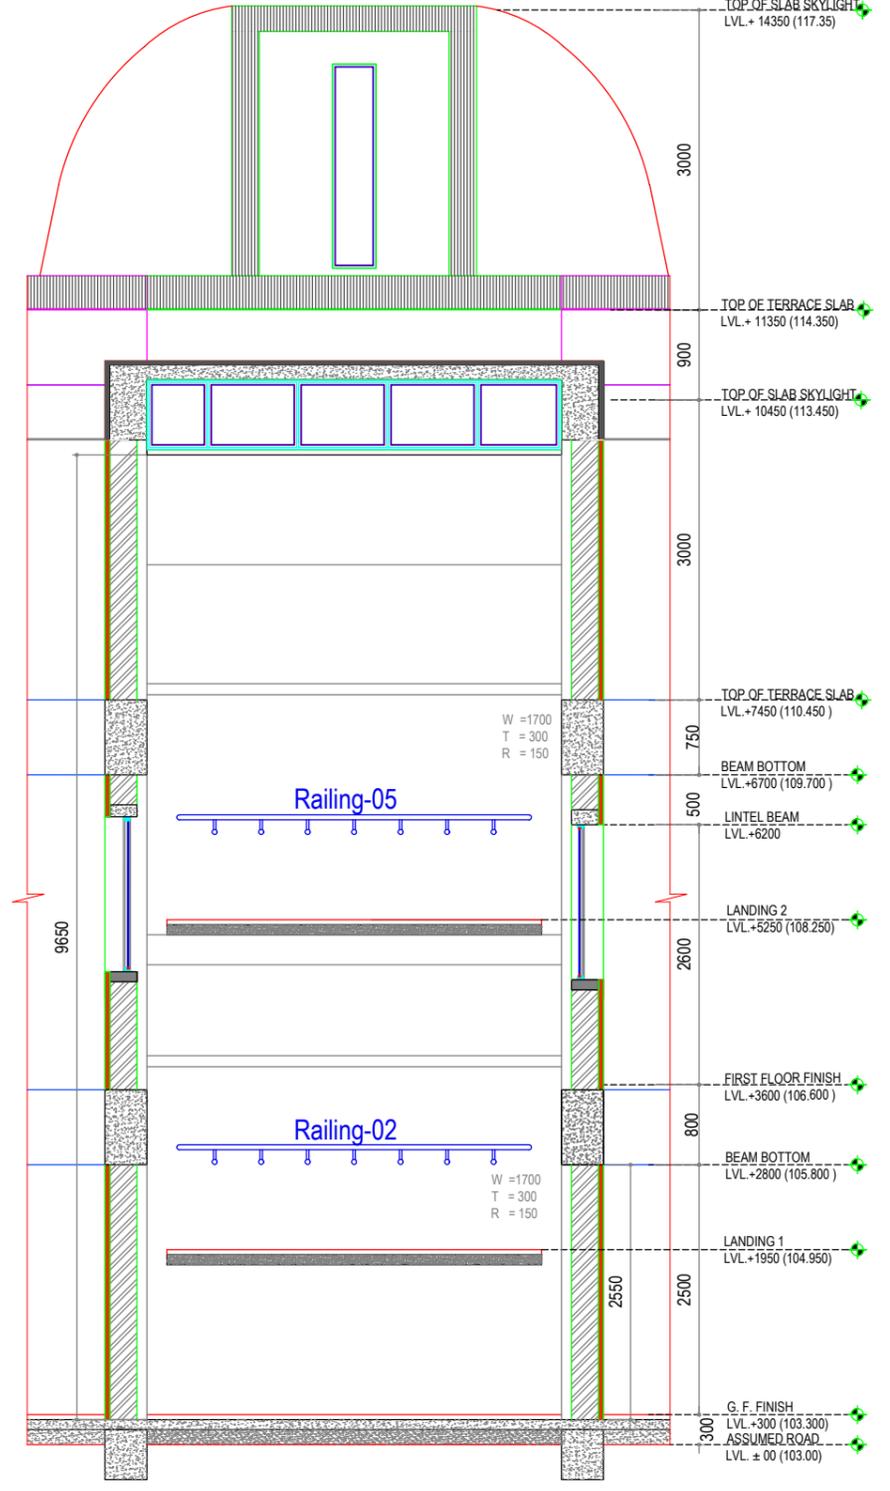


04 Elevation-A
SCALE 1:50


NOTE:
THIS DRAWING IS A COPYRIGHT. IT IS THE PROPERTY OF STUDIO VANRO AND IS NOT TO BE REPRODUCED, COPIED, HANDED OVER TO A THIRD PARTY OR USED FOR ANY PURPOSE OTHER THAN THAT FOR WHICH IT HAS BEEN LOANED.

GENERAL NOTES:
ALL DIMENSIONS INDICATED ARE IN MILLIMETER UNLESS MENTIONED OTHERWISE
ALL DIMENSIONS ARE TO BE CROSS CHECKED AT SITE AND ANY DISCREPANCY SHALL BE BROUGHT TO NOTICE BEFORE EXECUTION.
ALL SERVICE DRAWINGS SHALL BE READ IN CONJUNCTION WITH THIS DRAWING AND OTHER DETAILS.
ANY DISCREPANCIES IN DRAWING MUST BE REPORTED IMMEDIATELY TO PMC FOR FINAL DECISION.


S.NO	DATE	DRAWN	CHECKED	VERIFIED	REMARKS

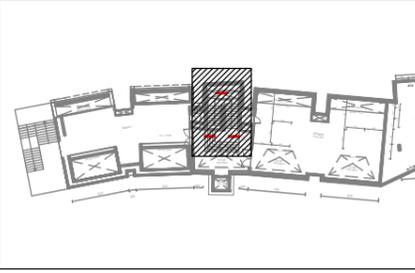

CLIENT		PROJECT	
J D Centre of Art		J D Centre of Art, Bhubaneswar	
ARCHITECT		DRAWING	
Vastu Shilpa Consultants/ Studio VanRO		STAIRCASE RAILING DETAIL (BLOCK-1)	
STRUCTURAL CONSULTANT		SCALE	
Mahendra Raj Consultants Pvt. Ltd		1:60 @ A2	
MUSEUM DESIGN		COMPUTER FILE	
Siddhartha Das Studio		JDCA_Bk1&2_Stair Railing Detail	
SANITARY, ELECTRICAL, HVAC, FIRE FIGHTING CONSULTANT		DRAWN BY	
		MAHESH PRAKASH	
		VIVEK NAMDEV	
		DATE	
		28-02-2025	
		DRAWING TITLE	

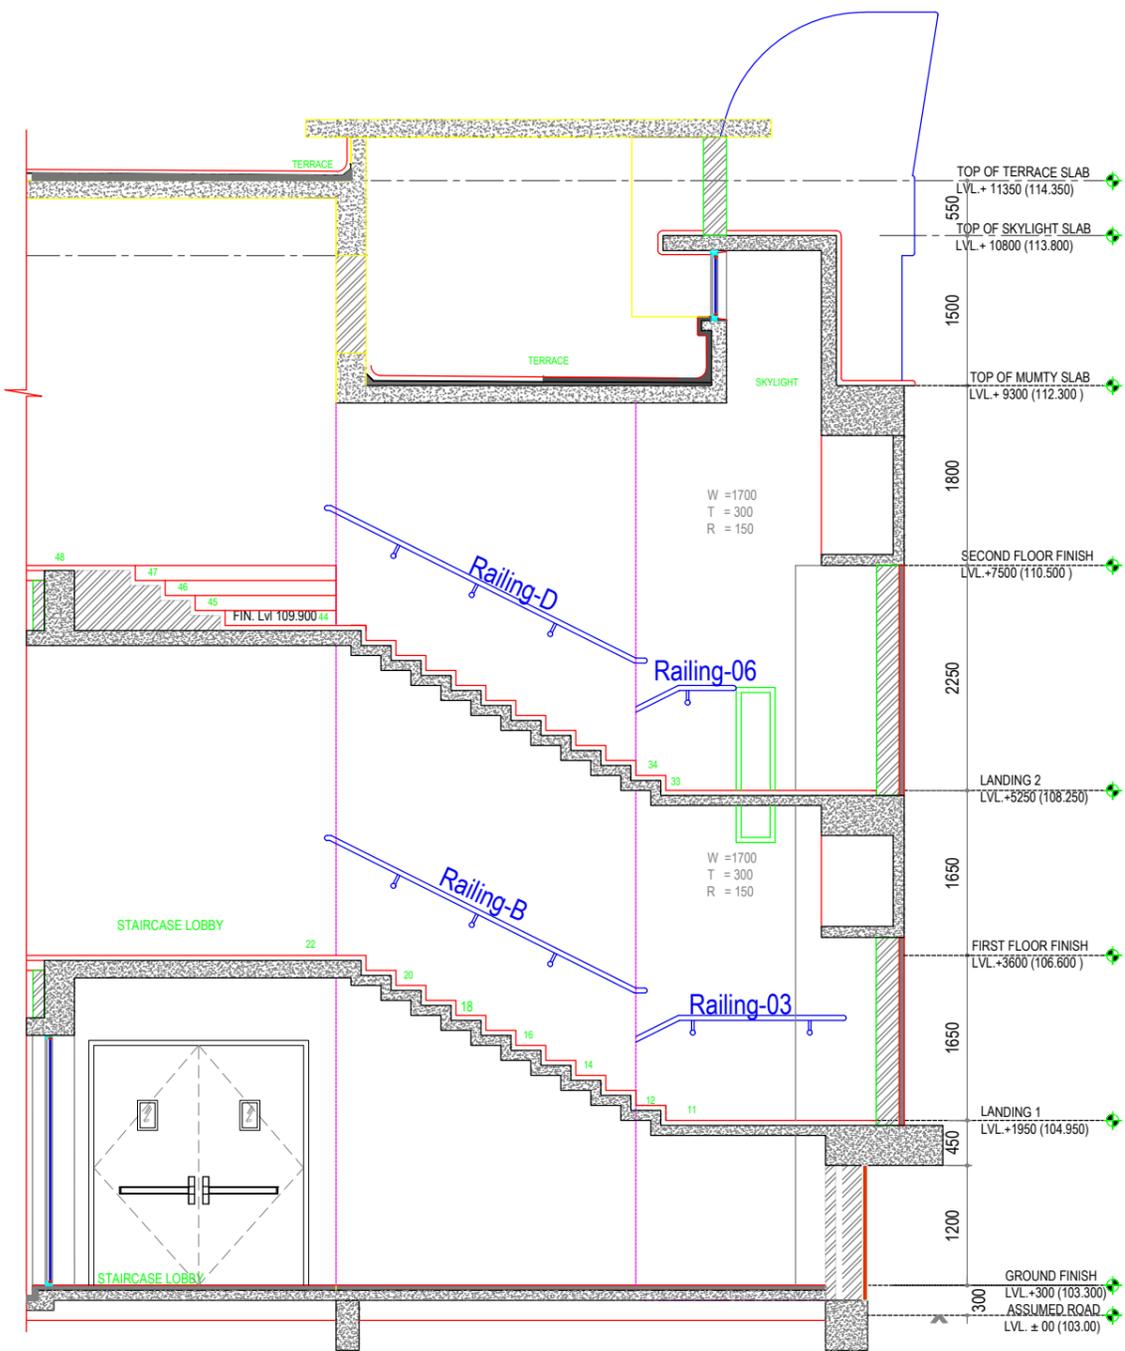

06 Elevation-F
SCALE 1:50

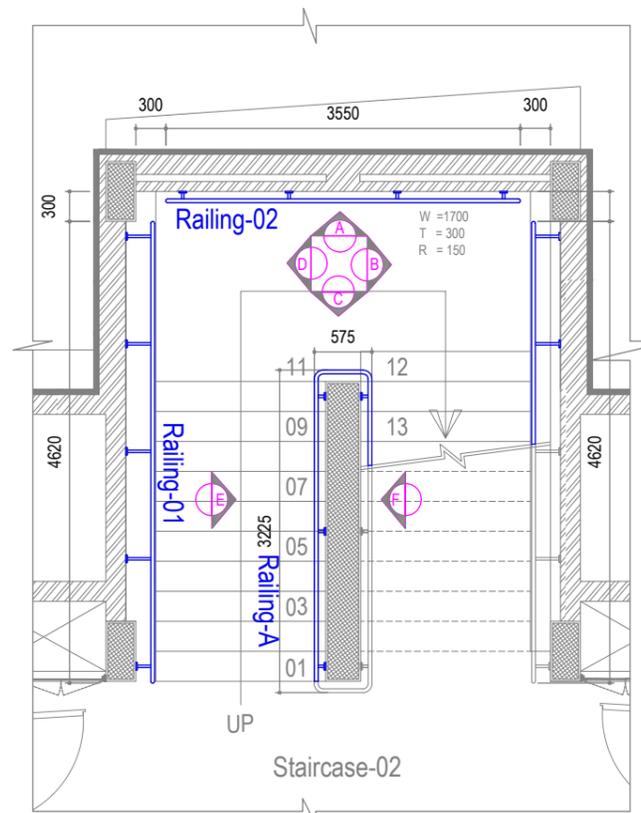


Key Plan

S.No	Railing	Length(m)
1	Railing-1	5.57
2	Railing-2	3.51
3	Railing-3	5.44
4	Railing-4	4.38
5	Railing-5	3.49
6	Railing-6	4.34
7	Railing-A	3.96
8	Railing-B	4.11
9	Railing-C	4.12
10	Railing-D	3.53
11	Railing-E	1.93
	Total	44.38

NOTE:
THIS DRAWING IS A COPYRIGHT. IT IS THE PROPERTY OF STUDIO VANRO AND IS NOT TO BE REPRODUCED, COPIED, HANDED OVER TO A THIRD PARTY OR USED FOR ANY PURPOSE OTHER THAN THAT FOR WHICH IT HAS BEEN LOANED.

GENERAL NOTES:
ALL DIMENSIONS INDICATED ARE IN MILLIMETER UNLESS MENTIONED OTHERWISE
ALL DIMENSIONS ARE TO BE CROSS CHECKED AT SITE AND ANY DISCREPANCY SHALL BE BROUGHT TO NOTICE BEFORE EXECUTION.
ALL SERVICE DRAWINGS SHALL BE READ IN CONJUNCTION WITH THIS DRAWING AND OTHER DETAILS.
ANY DISCREPANCIES IN DRAWING MUST BE REPORTED IMMEDIATELY TO PMC FOR FINAL DECISION.

S.NO	DATE	DRAWN	CHECKED	VERIFIED	REMARKS

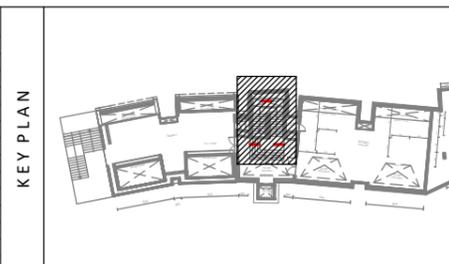

CLIENT		PROJECT	
J D Centre of Art		J D Centre of Art, Bhubaneswar	
ARCHITECT		DRAWING	
Vastu Shilpa Consultants/ Studio VanRO		STAIRCASE RAILING DETAIL (BLOCK-1)	
STRUCTURAL CONSULTANT		SCALE	COMPUTER FILE
Mahendra Raj Consultants Pvt. Ltd		1:60 @ A2	JDCA_Bk1&2_Stair Railing Detail
MUSEUM DESIGN		DRAWN BY	CHECKED BY
Siddhartha Das Studio		MAHESH PRAKASH	VIVEK NAMDEV
SANITARY, ELECTRICAL, HVAC, FIRE FIGHTING CONSULTANT		DATE	DRAWING TITLE
		28-02-2025	

